



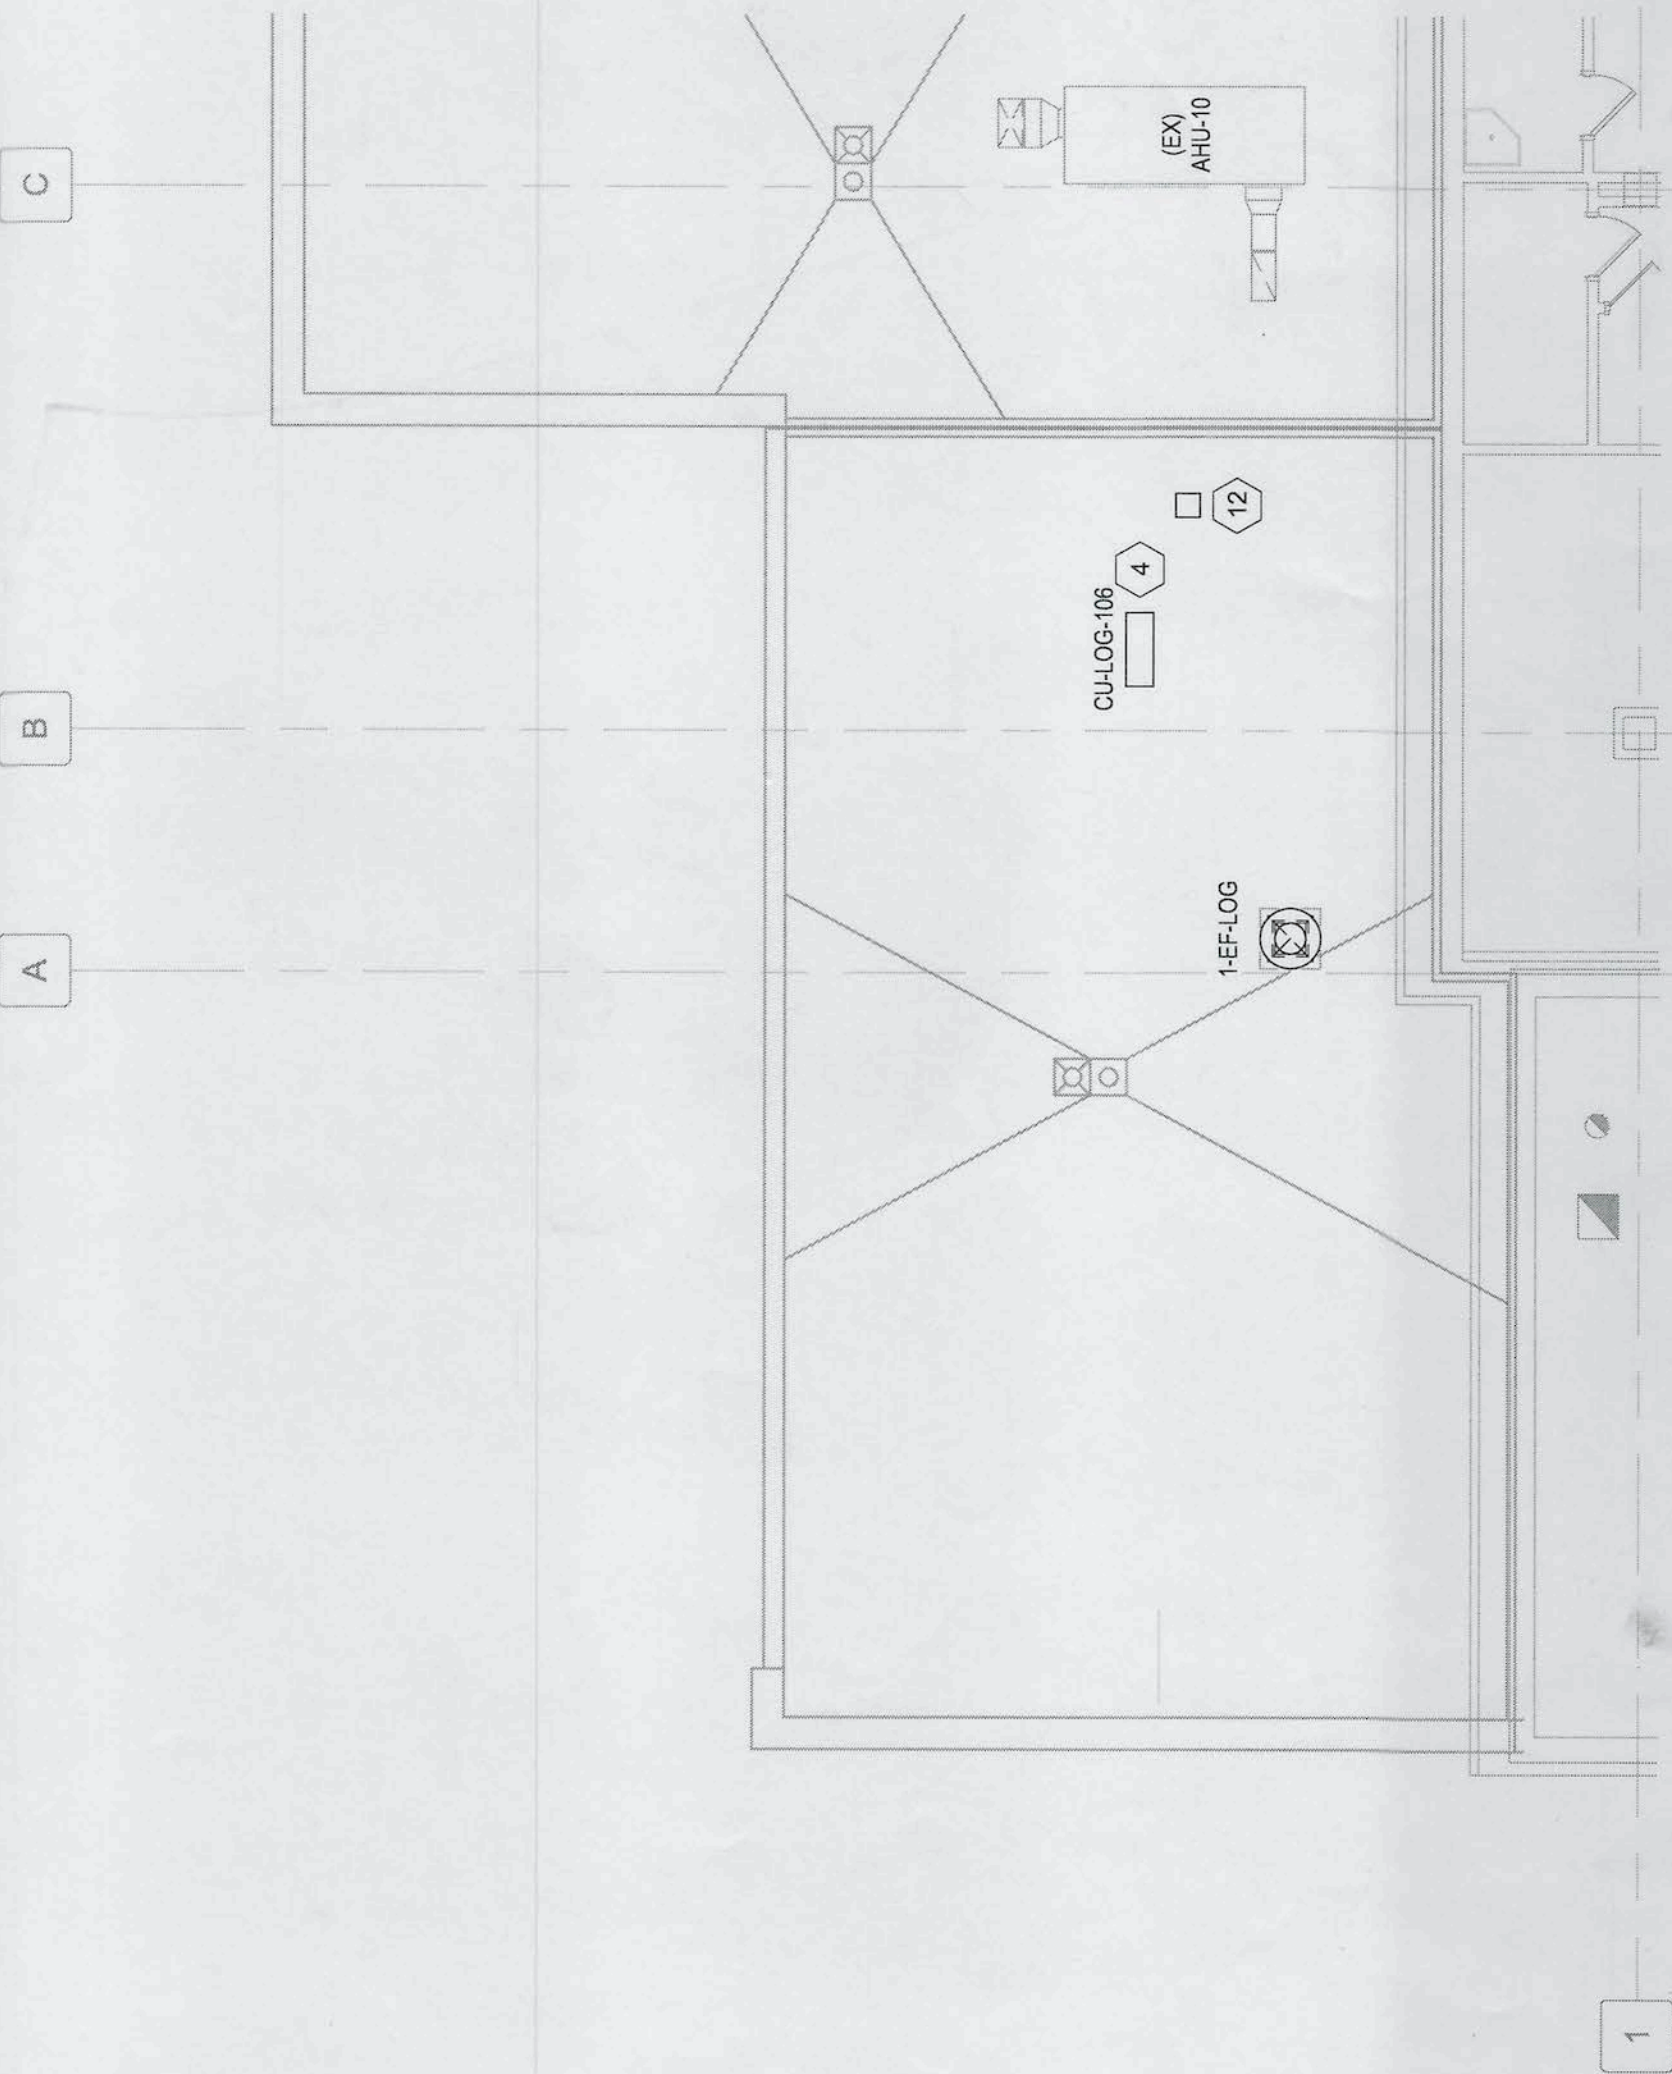

C1 **LOADING DOCK ROOF DUCTWORK PLAN**
1/8" = 1'-0"

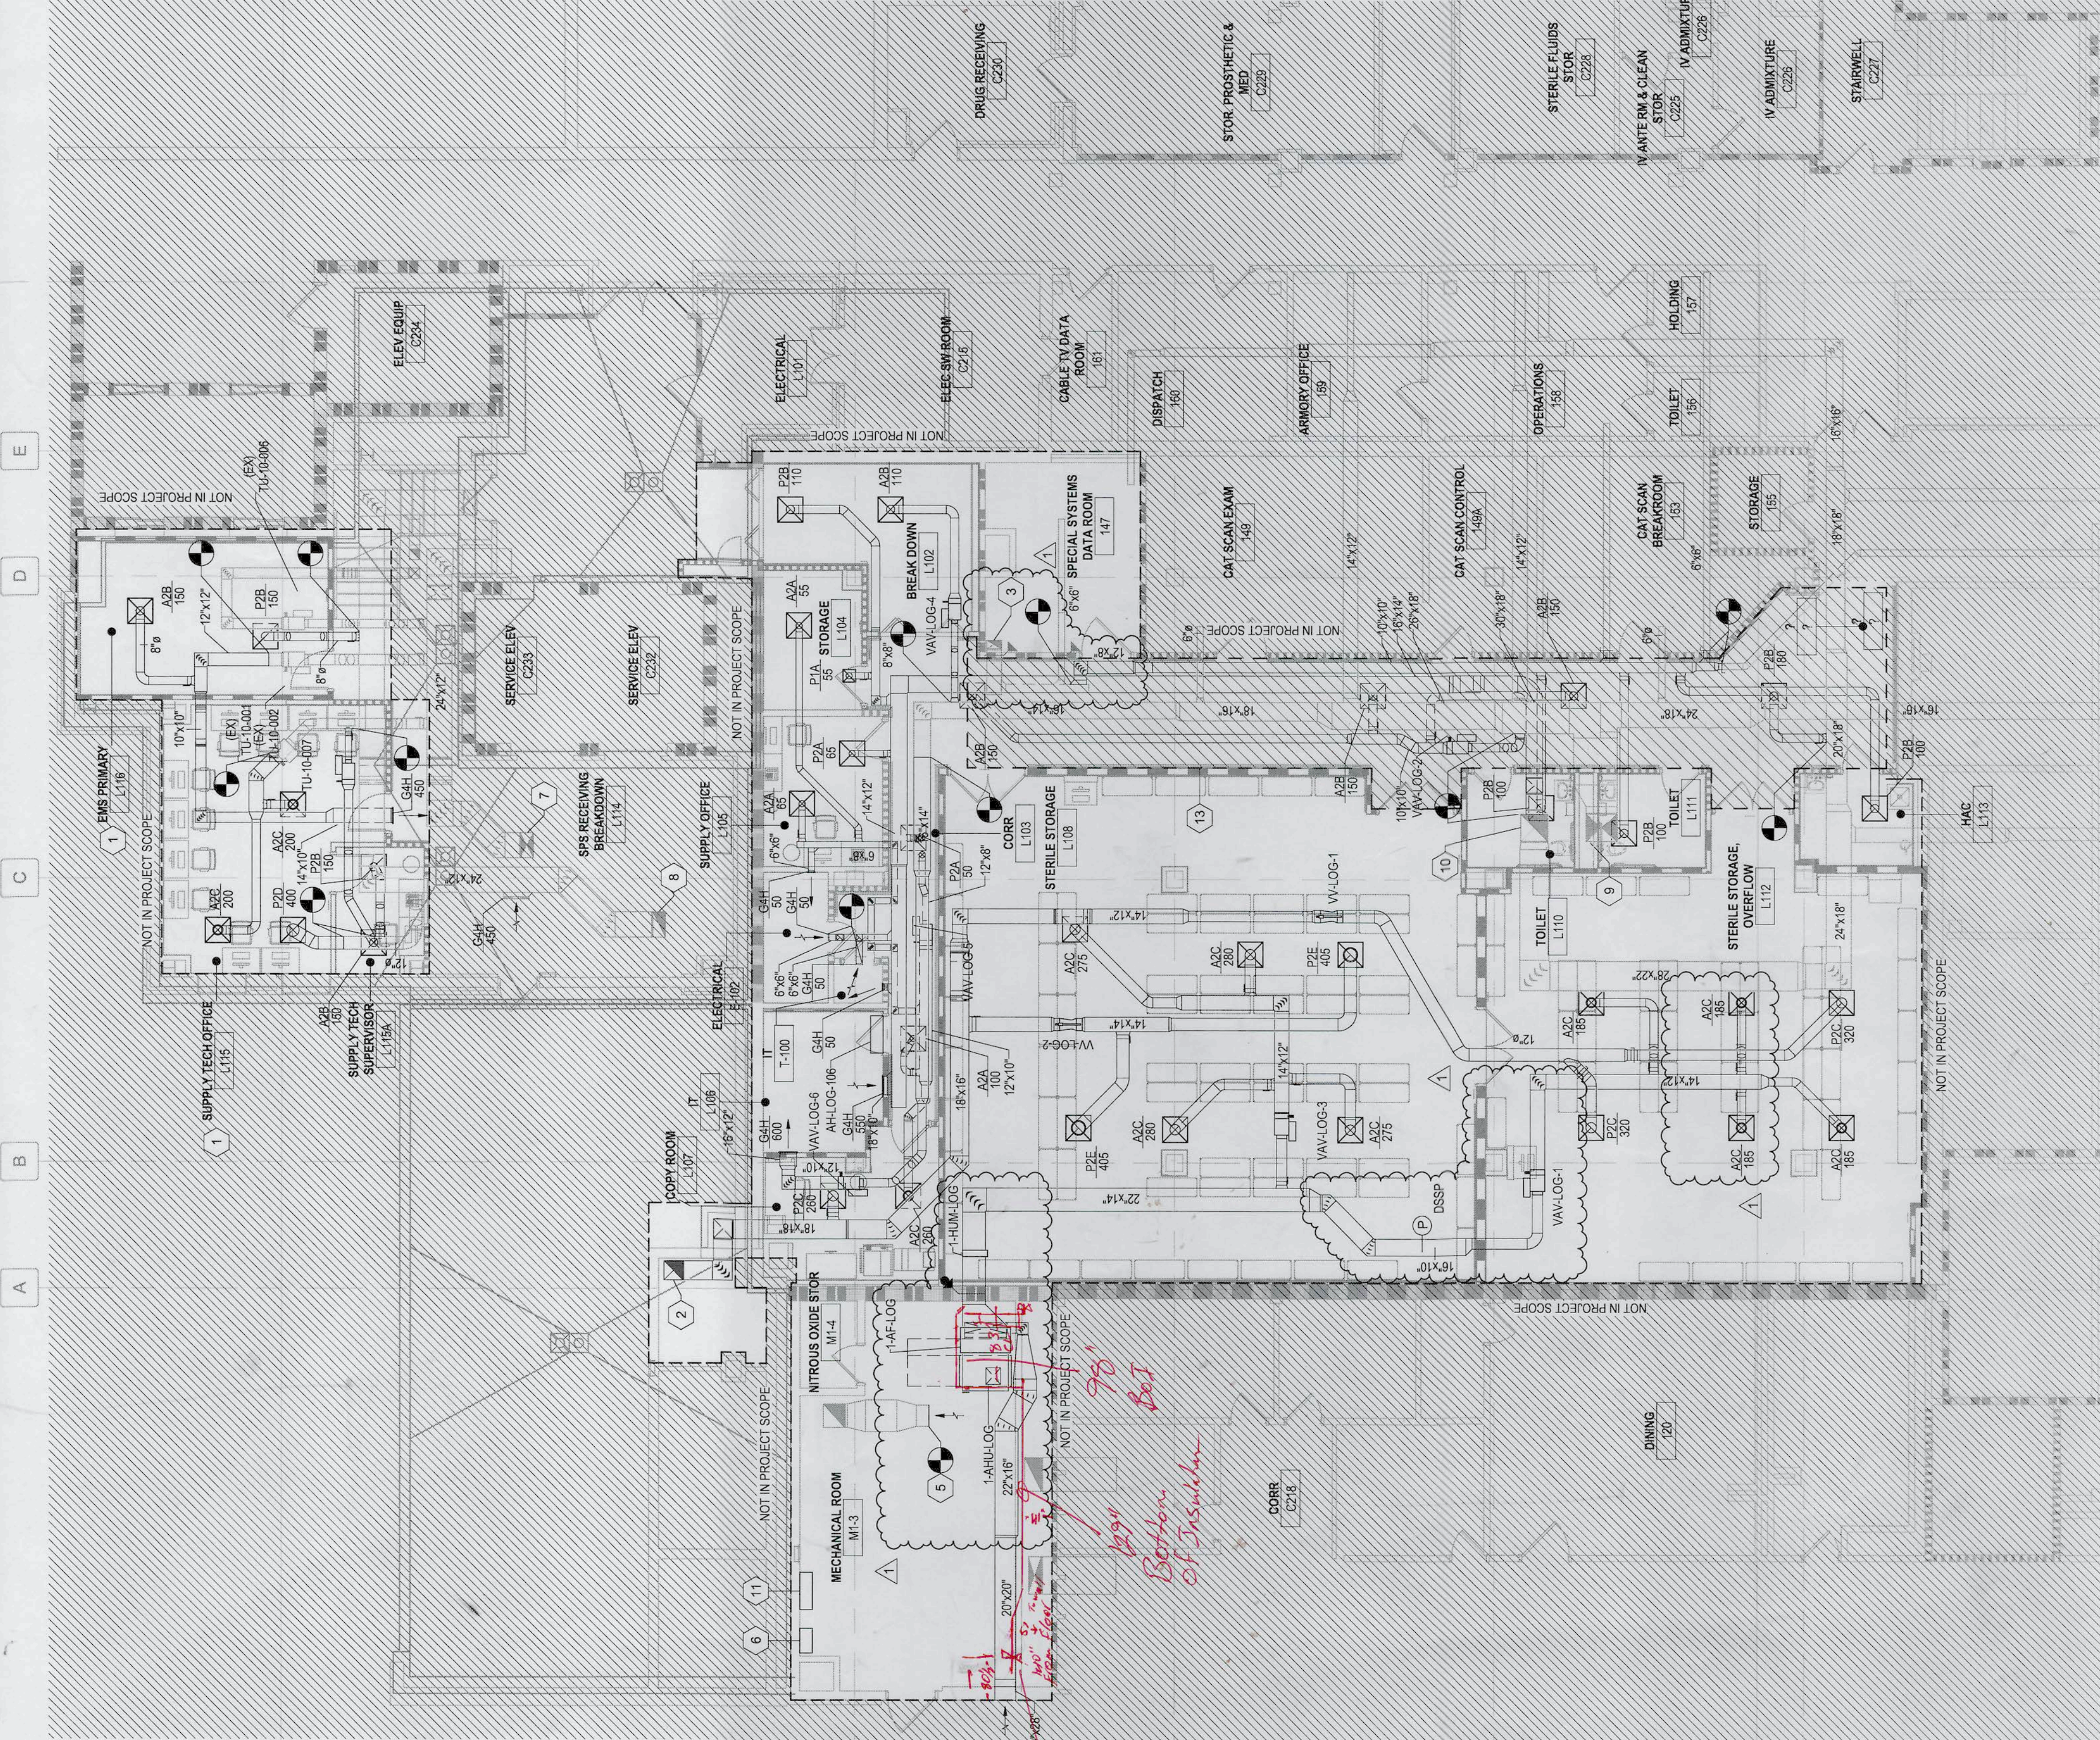

F4 **FIRST FLOOR DUCTWORK PLAN**
1/8" = 1'-0"

GENERAL NOTES

- 1. REFER TO SHEET MH101-A FOR LEGENDS, STANDARDS, AND ABBREVIATIONS.


SHEET KEYNOTES

- 1. PROVIDE NEW SUPPLY AND RETURN GRILLES IN THIS AREA. CONNECT TO EXISTING DUCTWORK.
- 2. EXISTING 14" X 12" EXHAUST DUCT TO FAN INLET SIZE BELOW LOADING DOCK.
- 3. EXISTING 14" X 12" EXHAUST DUCT UP TO EF-3.
- 4. ROUTE REFRIGERANT PIPING TO AIR HANDLER ON FIRST FLOOR.
- 5. REATTACH EXISTING NYTIME SCREEN/GRILLE.
- 6. SHIP FID IN INTERNAL BYPASS FOR 1-AHU-10.
- 7. SHIP FID IN INTERNAL BYPASS FOR 1-AHU-10.
- 8. EXISTING 24" X 12" RETURN DUCT UP TO 1-AHU-10.
- 9. EXISTING 30" X 26" SUPPLY DUCT DOWN FROM 1-AHU-10.
- 10. EXISTING 26" X 26" EXHAUST DUCT UP TO 1-EF-3.
- 11. BAS CONTROL PANEL.
- 12. ALL WORK IN CORRIDOR 100 MUST BE PERFORMED AFTER HOURS USING RATE CODE: PCC-1 OR APPROVED EQUAL WITH 3 PENETRATIONS. SEE SHEET AS111-A FOR MORE INFORMATION.
- 13. ALL WORK IN CORRIDOR 100 MUST BE PERFORMED AFTER HOURS USING RATE CODE: PCC-1 OR APPROVED EQUAL WITH 3 PENETRATIONS. SEE SHEET AS111-A FOR MORE INFORMATION.


PARTITION GRAPHICS

- NO RATING
- SMOKE RESISTIVE PARTITION - NON RATED
- 1 HOUR FIRE BARRIER
- 1 HOUR FIRE/SMOKE BARRIER
- 2 HOUR FIRE BARRIER
- 2 HOUR FIRE/SMOKE BARRIER

KEY PLAN

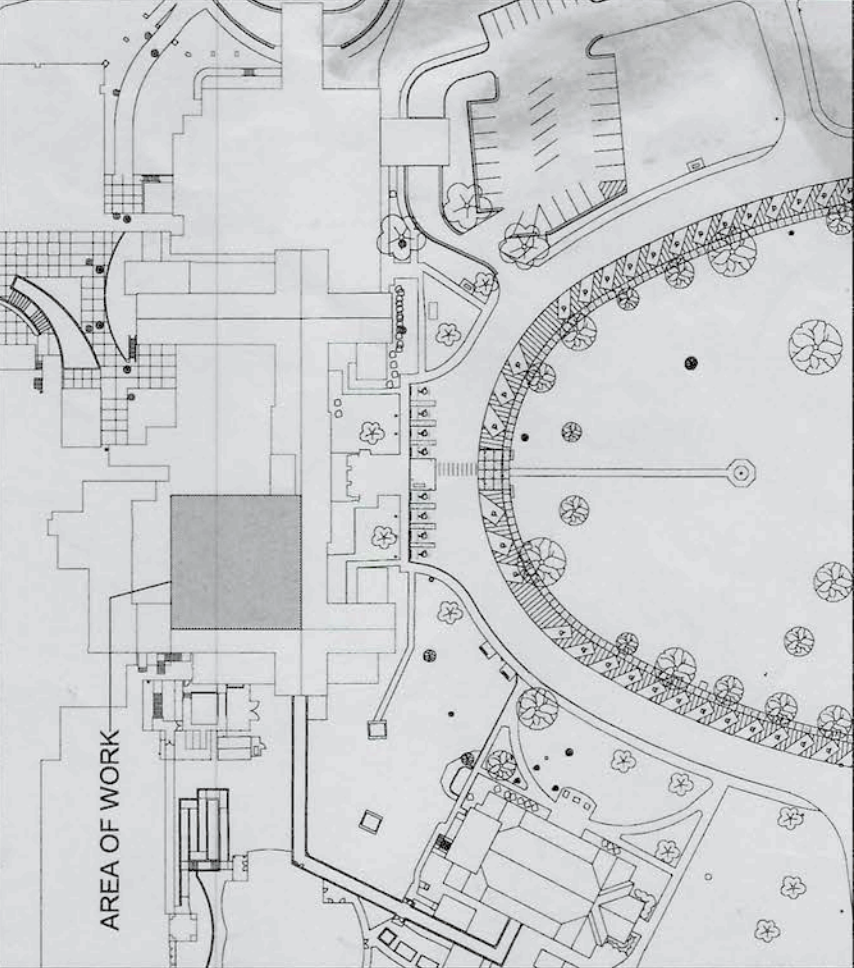

NORTH LEGEND

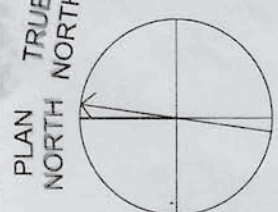

FIRST FLOOR - FFE 0'-0"

Revision Number	Revisions
1	AMENDMENT 02 Date: 07/11/2024

CONSULTANTS
CONSULTING STRUCTURAL ENGINEERS

BRITT, PETERS & ASSOCIATES, INC.

ARCHITECT/ENGINEER OF RECORD

A/E:
HARRELL DESIGN GROUP PC
10720 SIKES PLACE, SUITE 100
CHARLOTTE, NC 28277
704-814-1346
PETER HARRELL, PE, LEED AP, CC-P
PRESIDENT

HARRELL
DESIGN GROUP P.C.
WWW.HARRELLO.COM

DRAWING TITLE
FIRST FLOOR AND LOADING DOCK
ROOF DUCTWORK PLANS

PHASE
CONSTRUCTION
DOCUMENTS SUBMISSION

FULLY SPRINKLERED

PROJECT TITLE
RENOVATE SPACE FOR LOGISTICS
(B-1)

LOCATION
FAYETTEVILLE VA MEDICAL CENTER

ISSUE DATE
11 APRIL 2024

CHECKED
DRAWN
WMB
AMB

PROJECT NUMBER
564-24-104

BUILDING NUMBER
1

DRAWING NUMBER
MH101-A

Engineering Service
VETERANS HEALTH CARE SYSTEM
OF THE OASAS
U.S. Department of Veterans Affairs