

PRELIMINARY
 NOT FOR
 CONSTRUCTION

Revision Schedule	Description
Rev. #	Date


NWA PEDIATRICS ADDITION
 3730 S PINNACLE HILLS PKWY #3
 ROGERS, AR 72758

MANA
 3383 N MANA CT, SUITE 201
 FAYETTEVILLE, AR 72703

DATE	DRAWN BY
Issue Date	Designer
PROJECT #	CHECKED BY
2438	Checker

SHEET
E1.1
 ELECTRICAL POWER PLAN

These Drawings and Specifications are the exclusive property of Key Architecture Inc. and are protected by Copyright. Use or reproduction is prohibited without written consent.

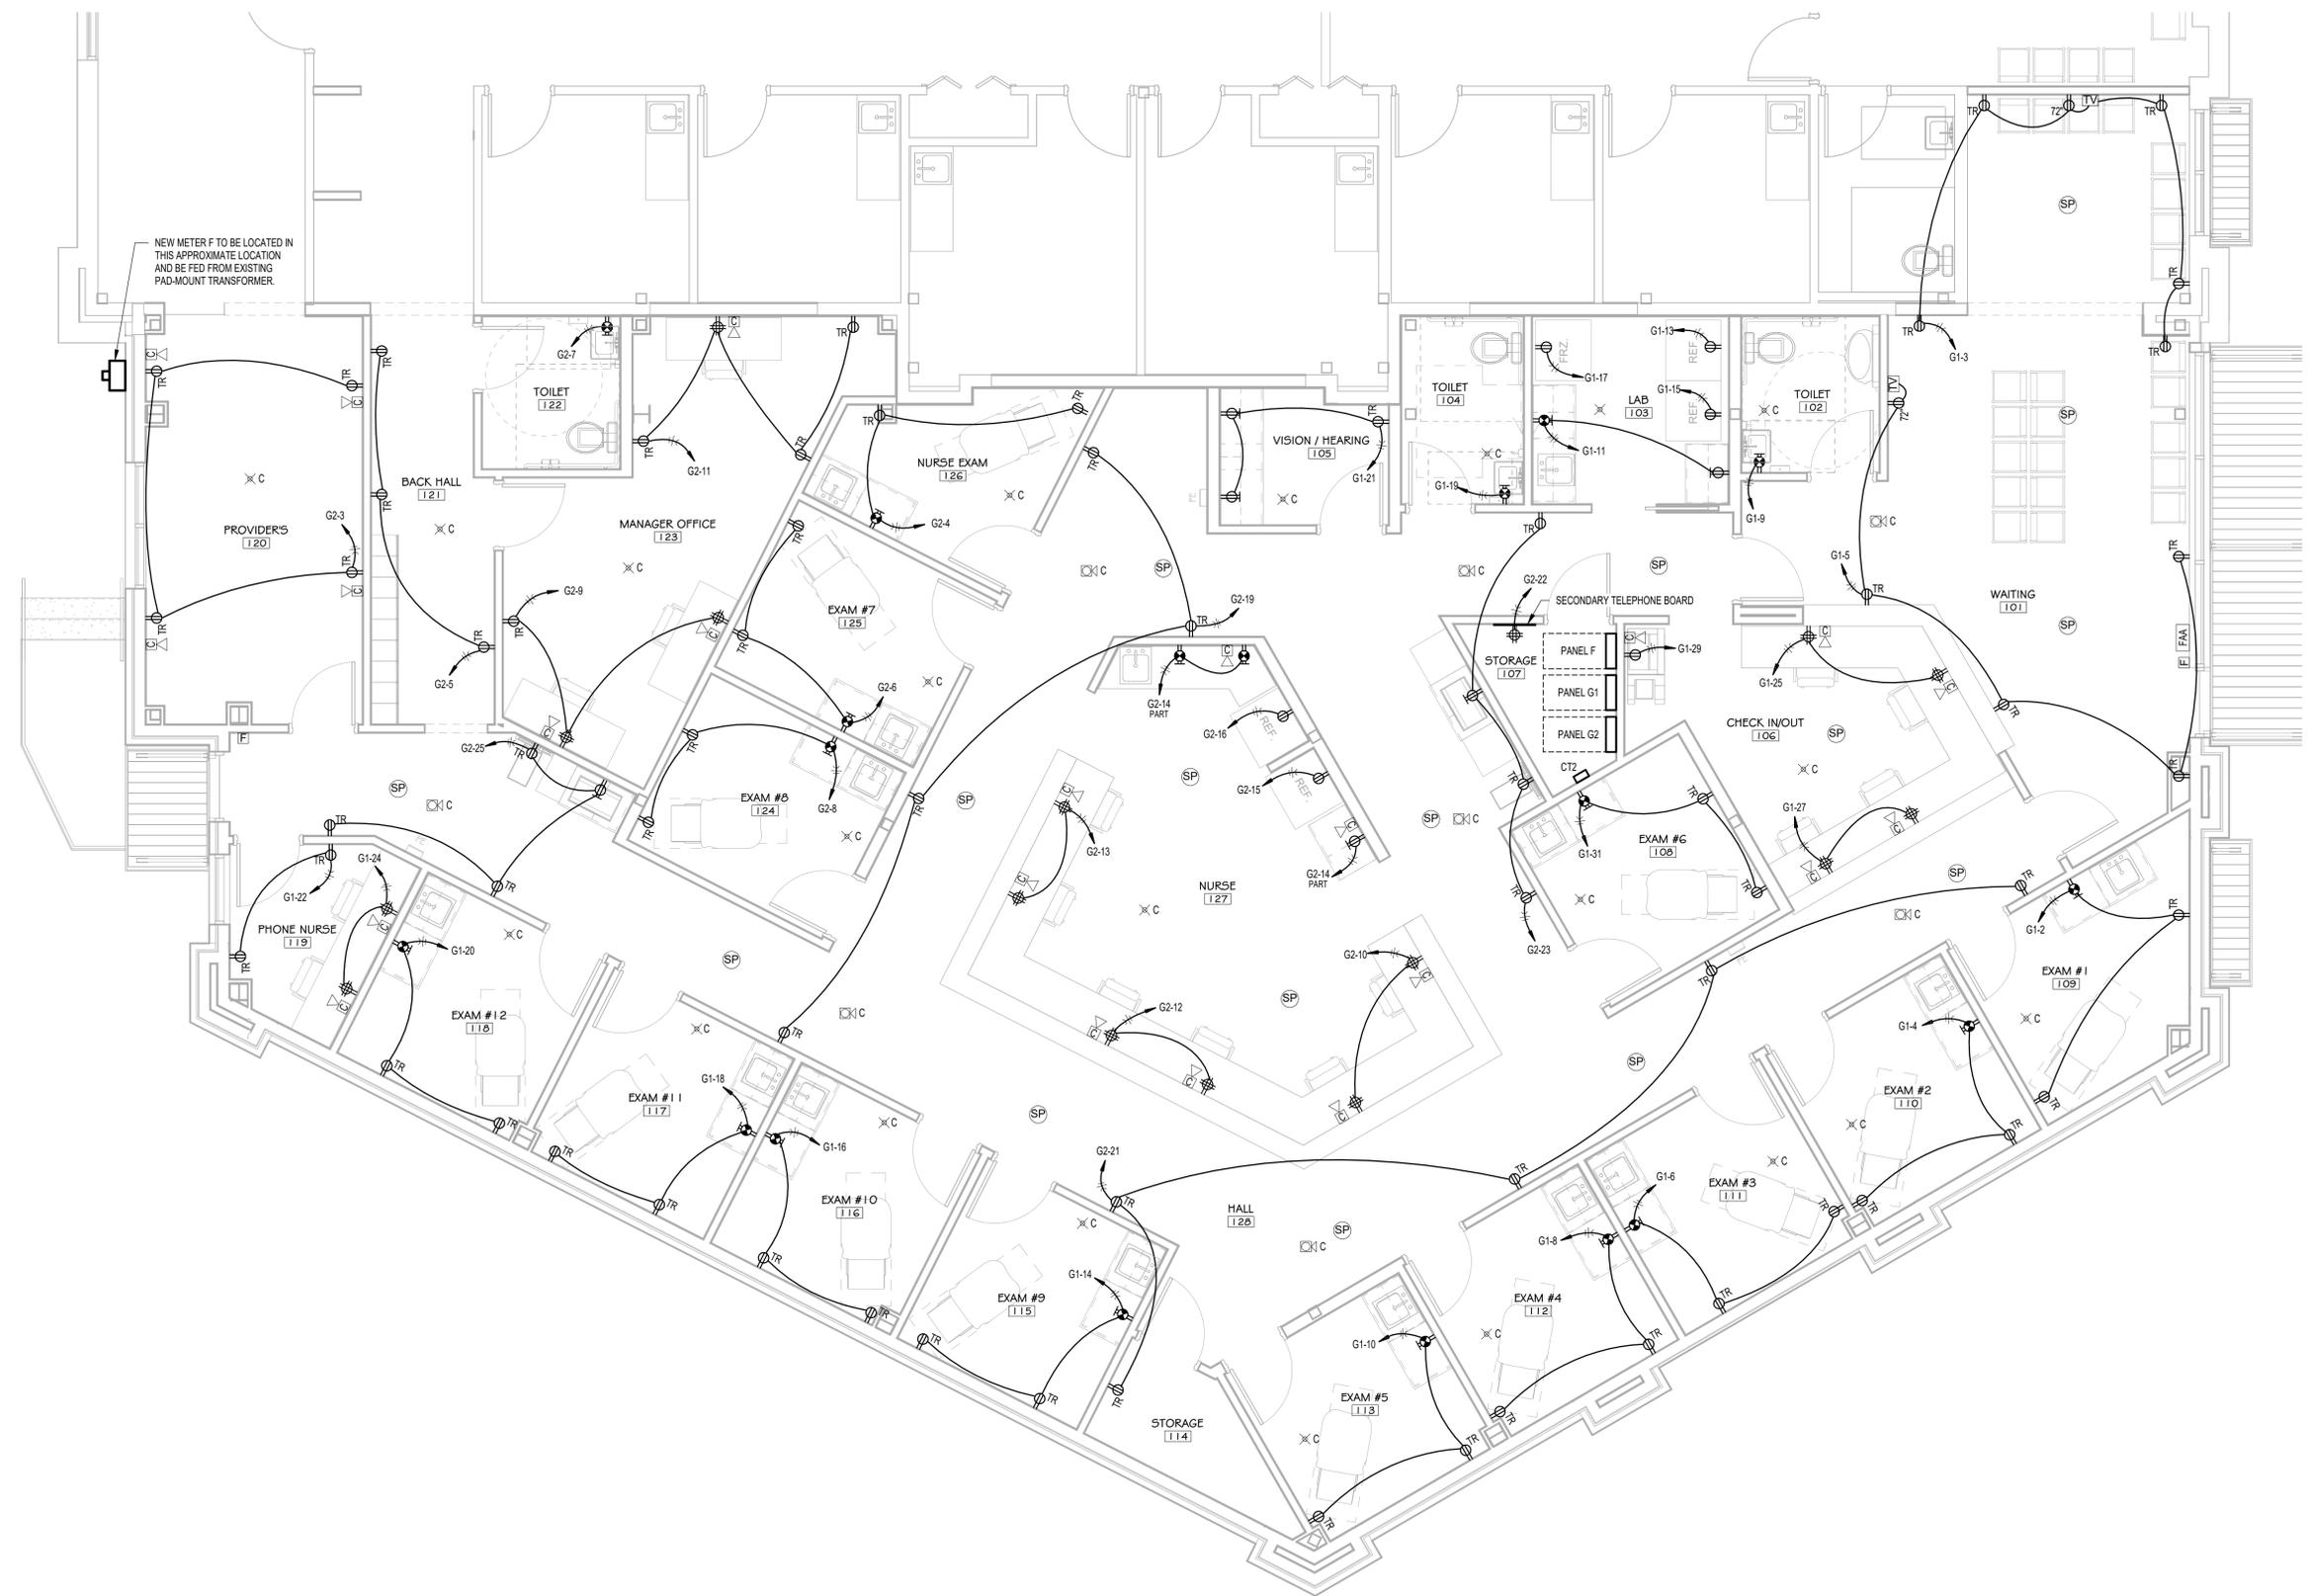

1 ELECTRICAL POWER PLAN
 SCALE: 1/4" = 1'-0"