


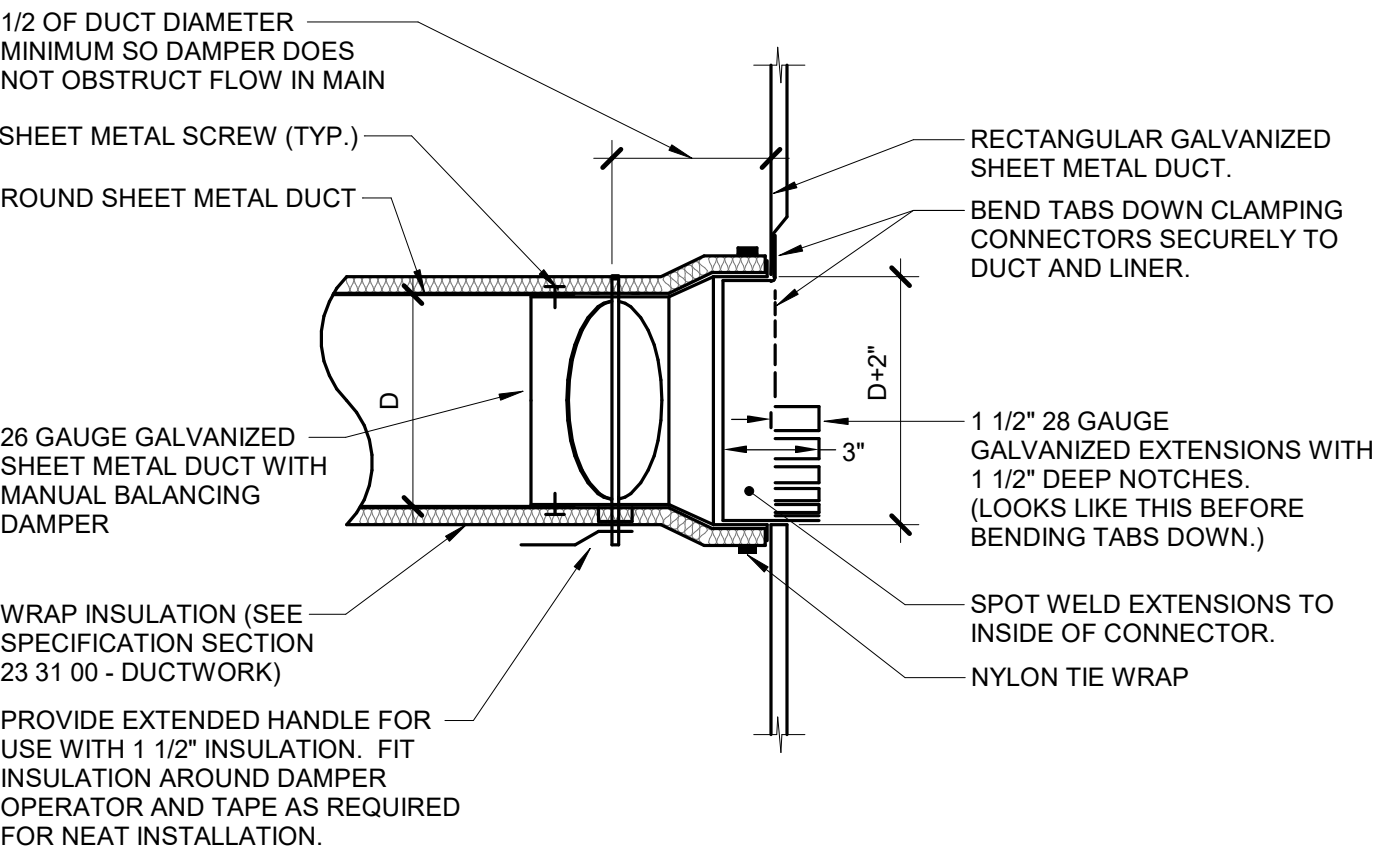


NOTES:

1. THIS DETAIL APPLIES ONLY TO TAPS OFF LINED DUCTS.
2. TAP DOES NOT NEED TO BE CONICAL IF THE TAP IS NOT LOCATED BETWEEN FANS AND TERMINAL AIR BOXES. DUCT IS NOT OVER 2" PRESSURE CLASS, AND ROUND DUCT IS NOT OVER 12" DIAMETER.


1 DUCT - FLEX CONICAL TO LINED DUCT W/BALANCING DAMPER

NO SCALE

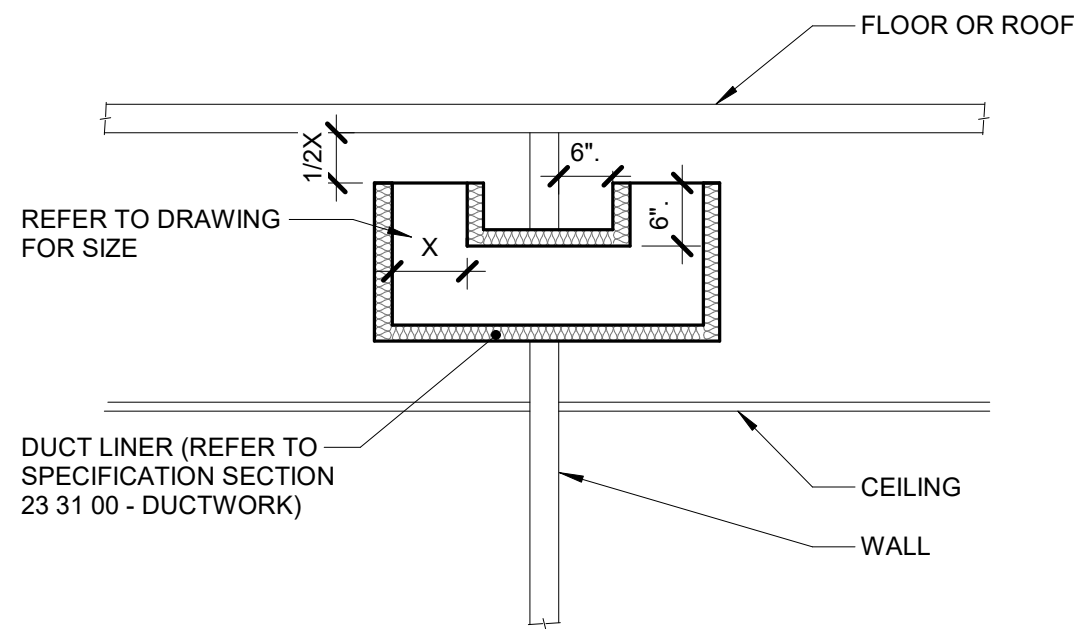


2 TRANSFER DUCT - ELBOW ENDS

NO SCALE

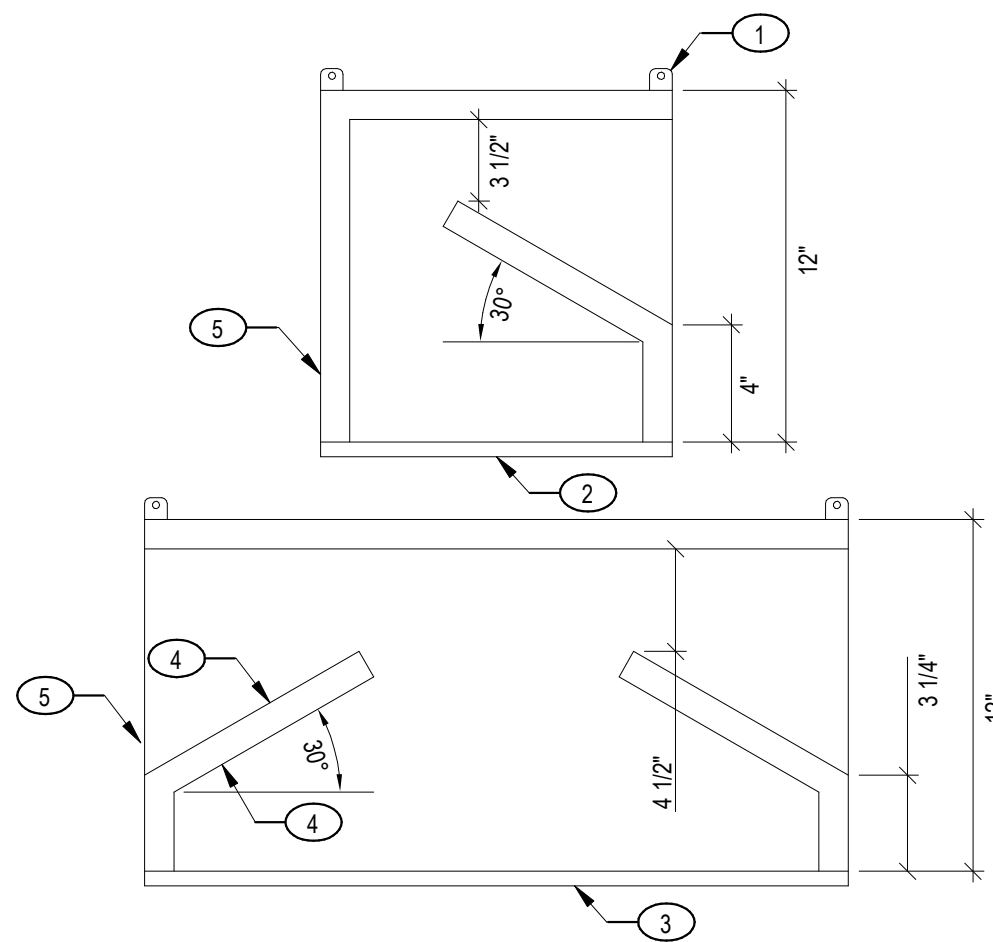

3 TYPICAL RETURN AIR GRILLE SOUND BOOT

3/4" = 1'-0"

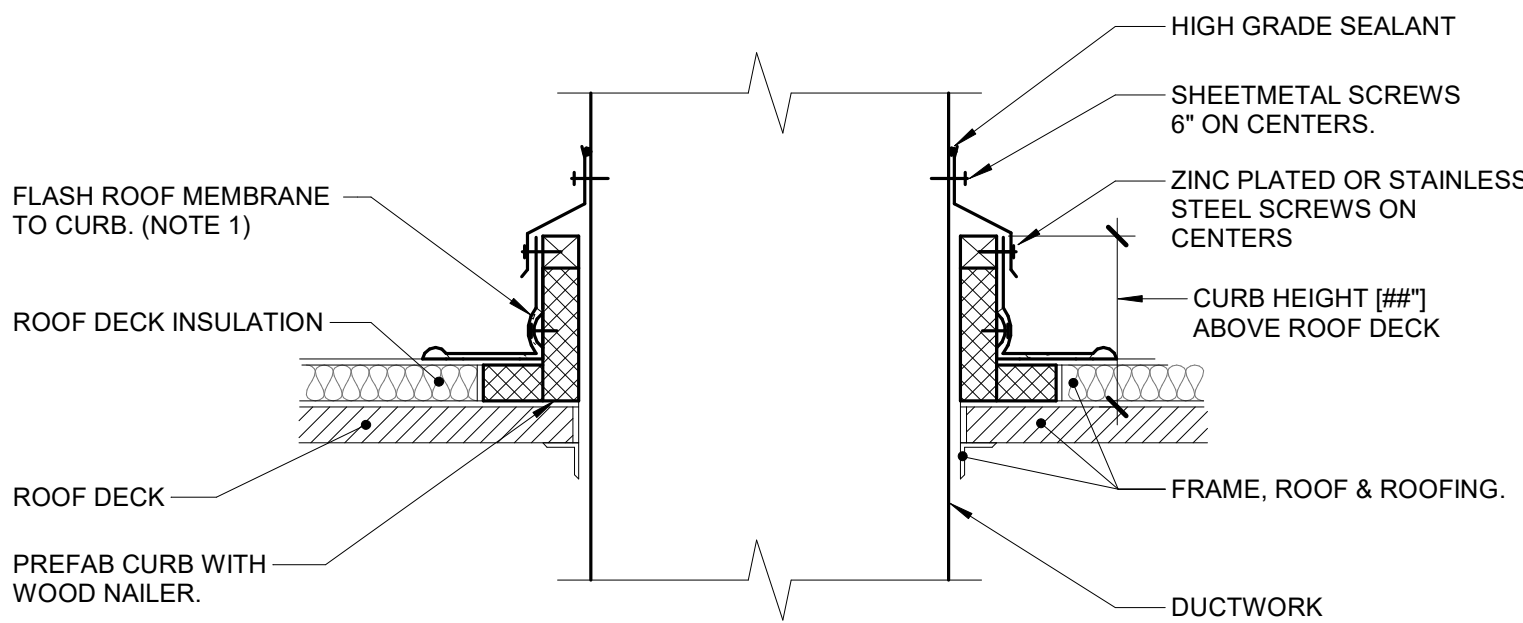

NOTES:

1. ALL ROOF FLASHING SHALL BE PER ROOF MANUFACTURER'S RECOMMENDATIONS.

4 ROOF PENETRATION - STEEL DUCT RECTANGULAR

12" = 1'-0"

KEYNOTES:

1. SUPPORT HANGER
2. 12" x 24" RETURN GRILLE
3. 24" x 24" RETURN GRILLE
4. 1" DUCT LINER TRIM AND SEAL ALL JOINTS
5. 26 GAUGE SHEET METAL

NOTES:

- A. TYPICAL OF ALL RETURN GRILLES INSTALLED IN RETURN AIR PLENUM

issue for review:	2026.08.05	
issue for pricing:	2026.09.11	
issue for construction:		
revisions:		
mark	date	description

modus
studio
architecture
+prototyping
479.455.5577
modusstudio.com
contact@modusstudio.com



NOT FOR
CONSTRUCTION

WACHTER

REFER TO SHEETS G020 - G023 FOR ALL GENERAL NOTES RELATIVE TO THE SCOPE OF WORK AND TYPE OF DRAWINGS, DIMENSIONS, AND INSTRUCTIONS FOUND ON THIS SHEET.

PLEASE REFER TO CONTRACTOR PROVIDED TRADE PACKAGES DIVISION 05 FOR ALL CONTRACTOR PROJECT REQUIREMENTS. WITHOUT EXCEPTION, ALL SUBCONTRACTORS ARE RESPONSIBLE FOR REVIEWING ALL CONTRACT DOCUMENTS INCLUDING SHEETS, DRAWINGS, GENERAL NOTES, SPECIFICATIONS, ETC. AS PROVIDED BY THE ARCHITECT OR ANY OTHER CONSULTANT.

contents:
HVAC DETAILS

design: CD
date: 2026.09.11
project: 25.18



IMEG RESERVES PROPRIETARY RIGHTS, INCLUDING COPYRIGHTS, TO THIS DRAWING AND THE DATA SHOWN THEREON. SAID DRAWING AND/OR DATA ARE THE EXCLUSIVE PROPERTY OF IMEG AND SHALL NOT BE USED OR REPRODUCED FOR ANY OTHER PROJECT WITHOUT THE EXPRESS WRITTEN APPROVAL AND PARTICIPATION OF IMEG.
©2026 IMEG CONSULTANTS CORP.
Arkansas Certificate of Authorization #6308

PROJECT #260034

M4.03