

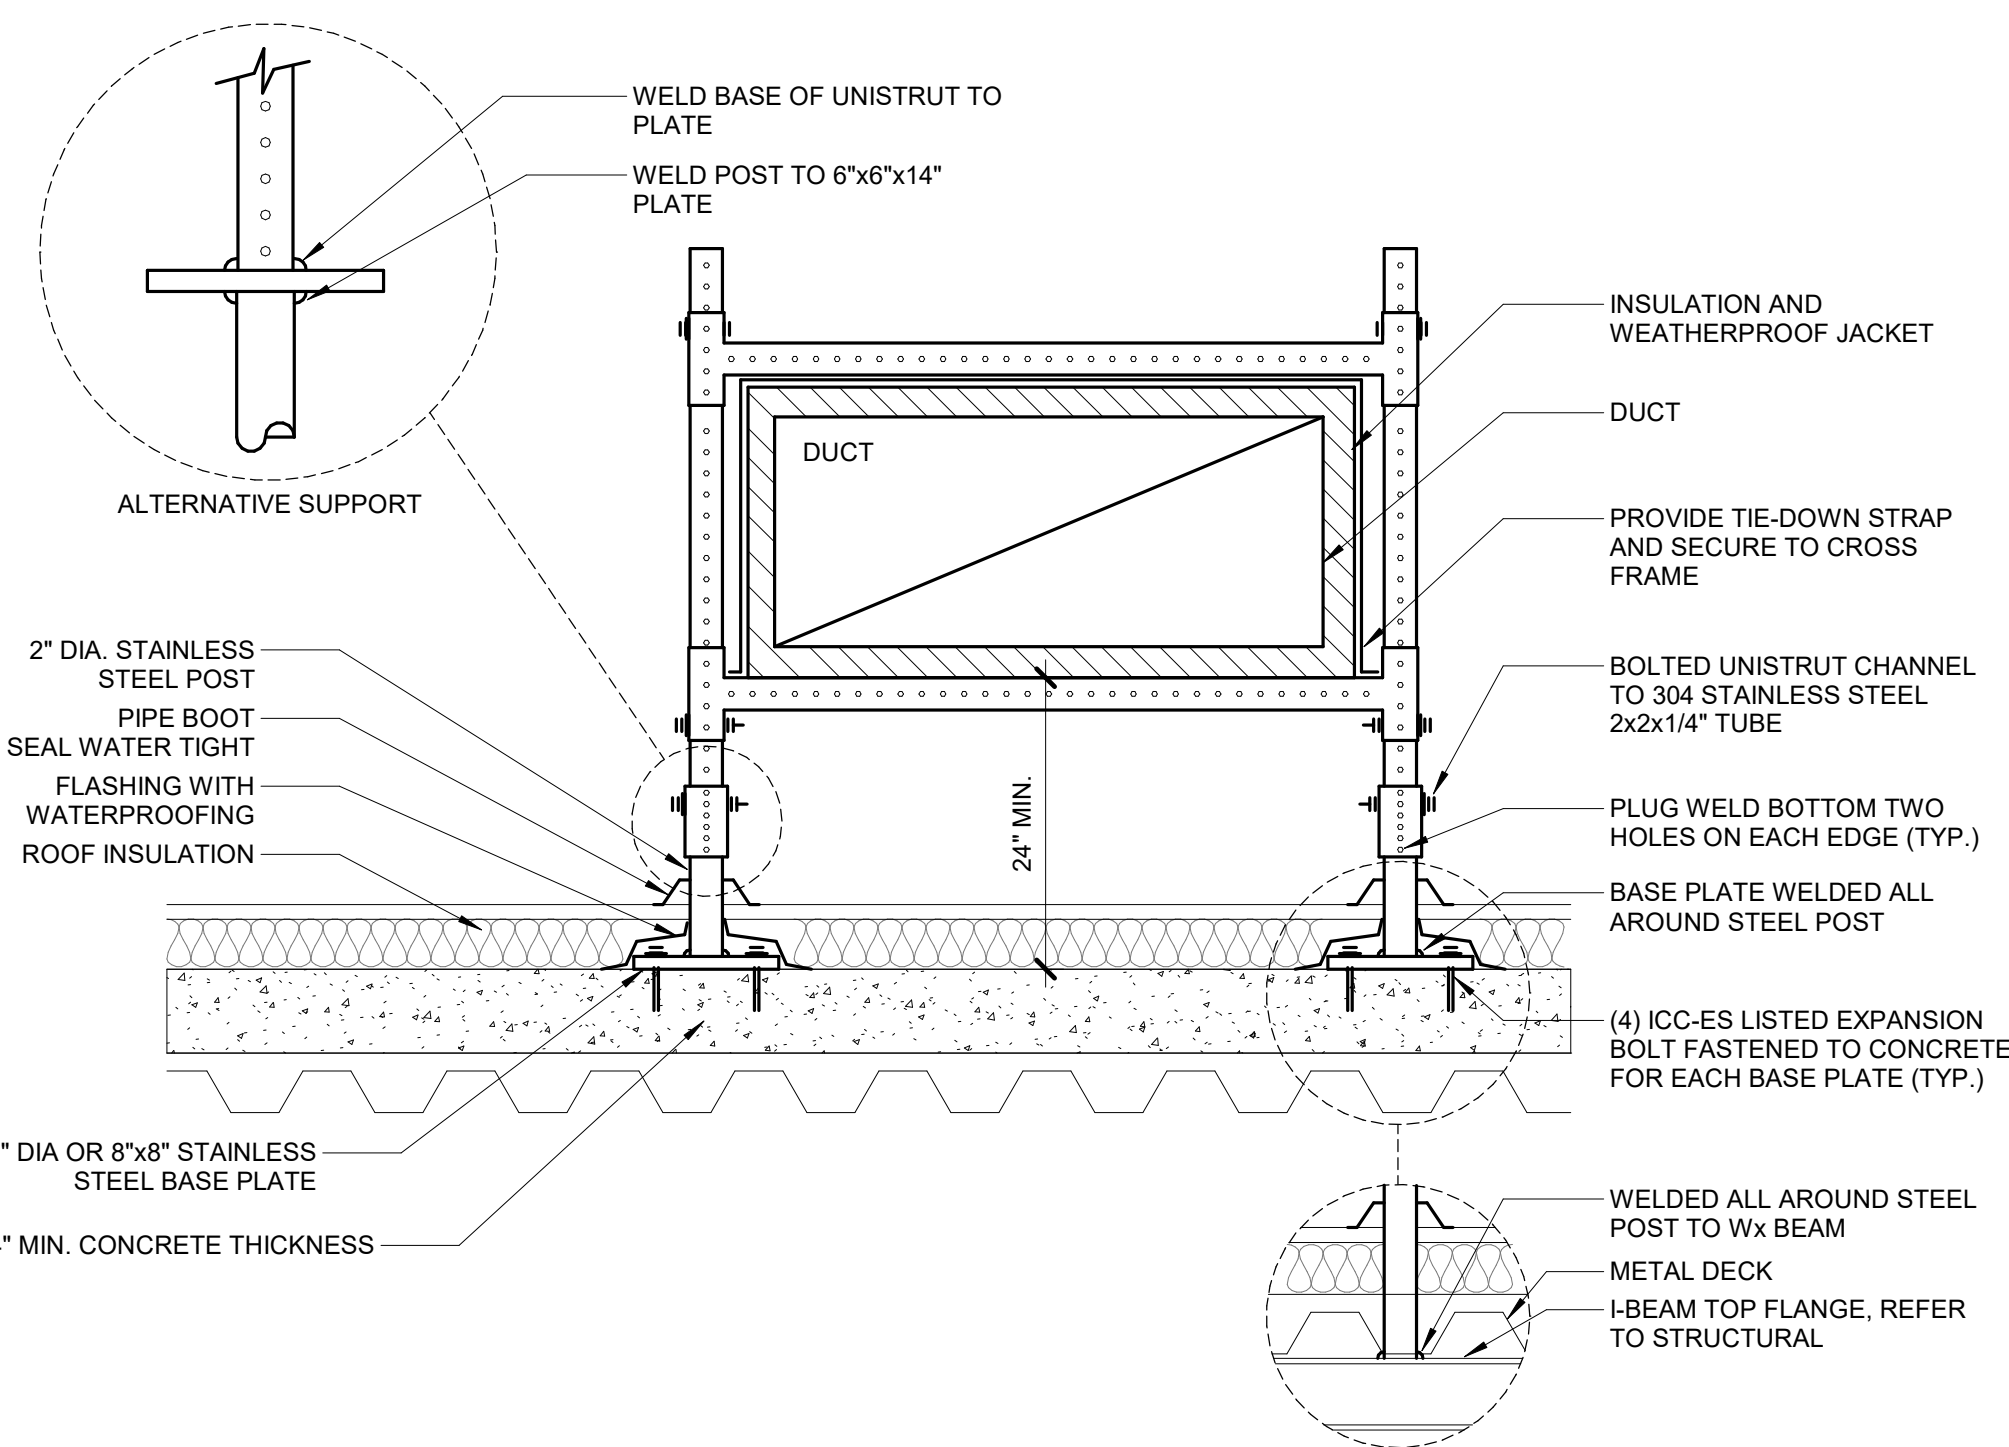
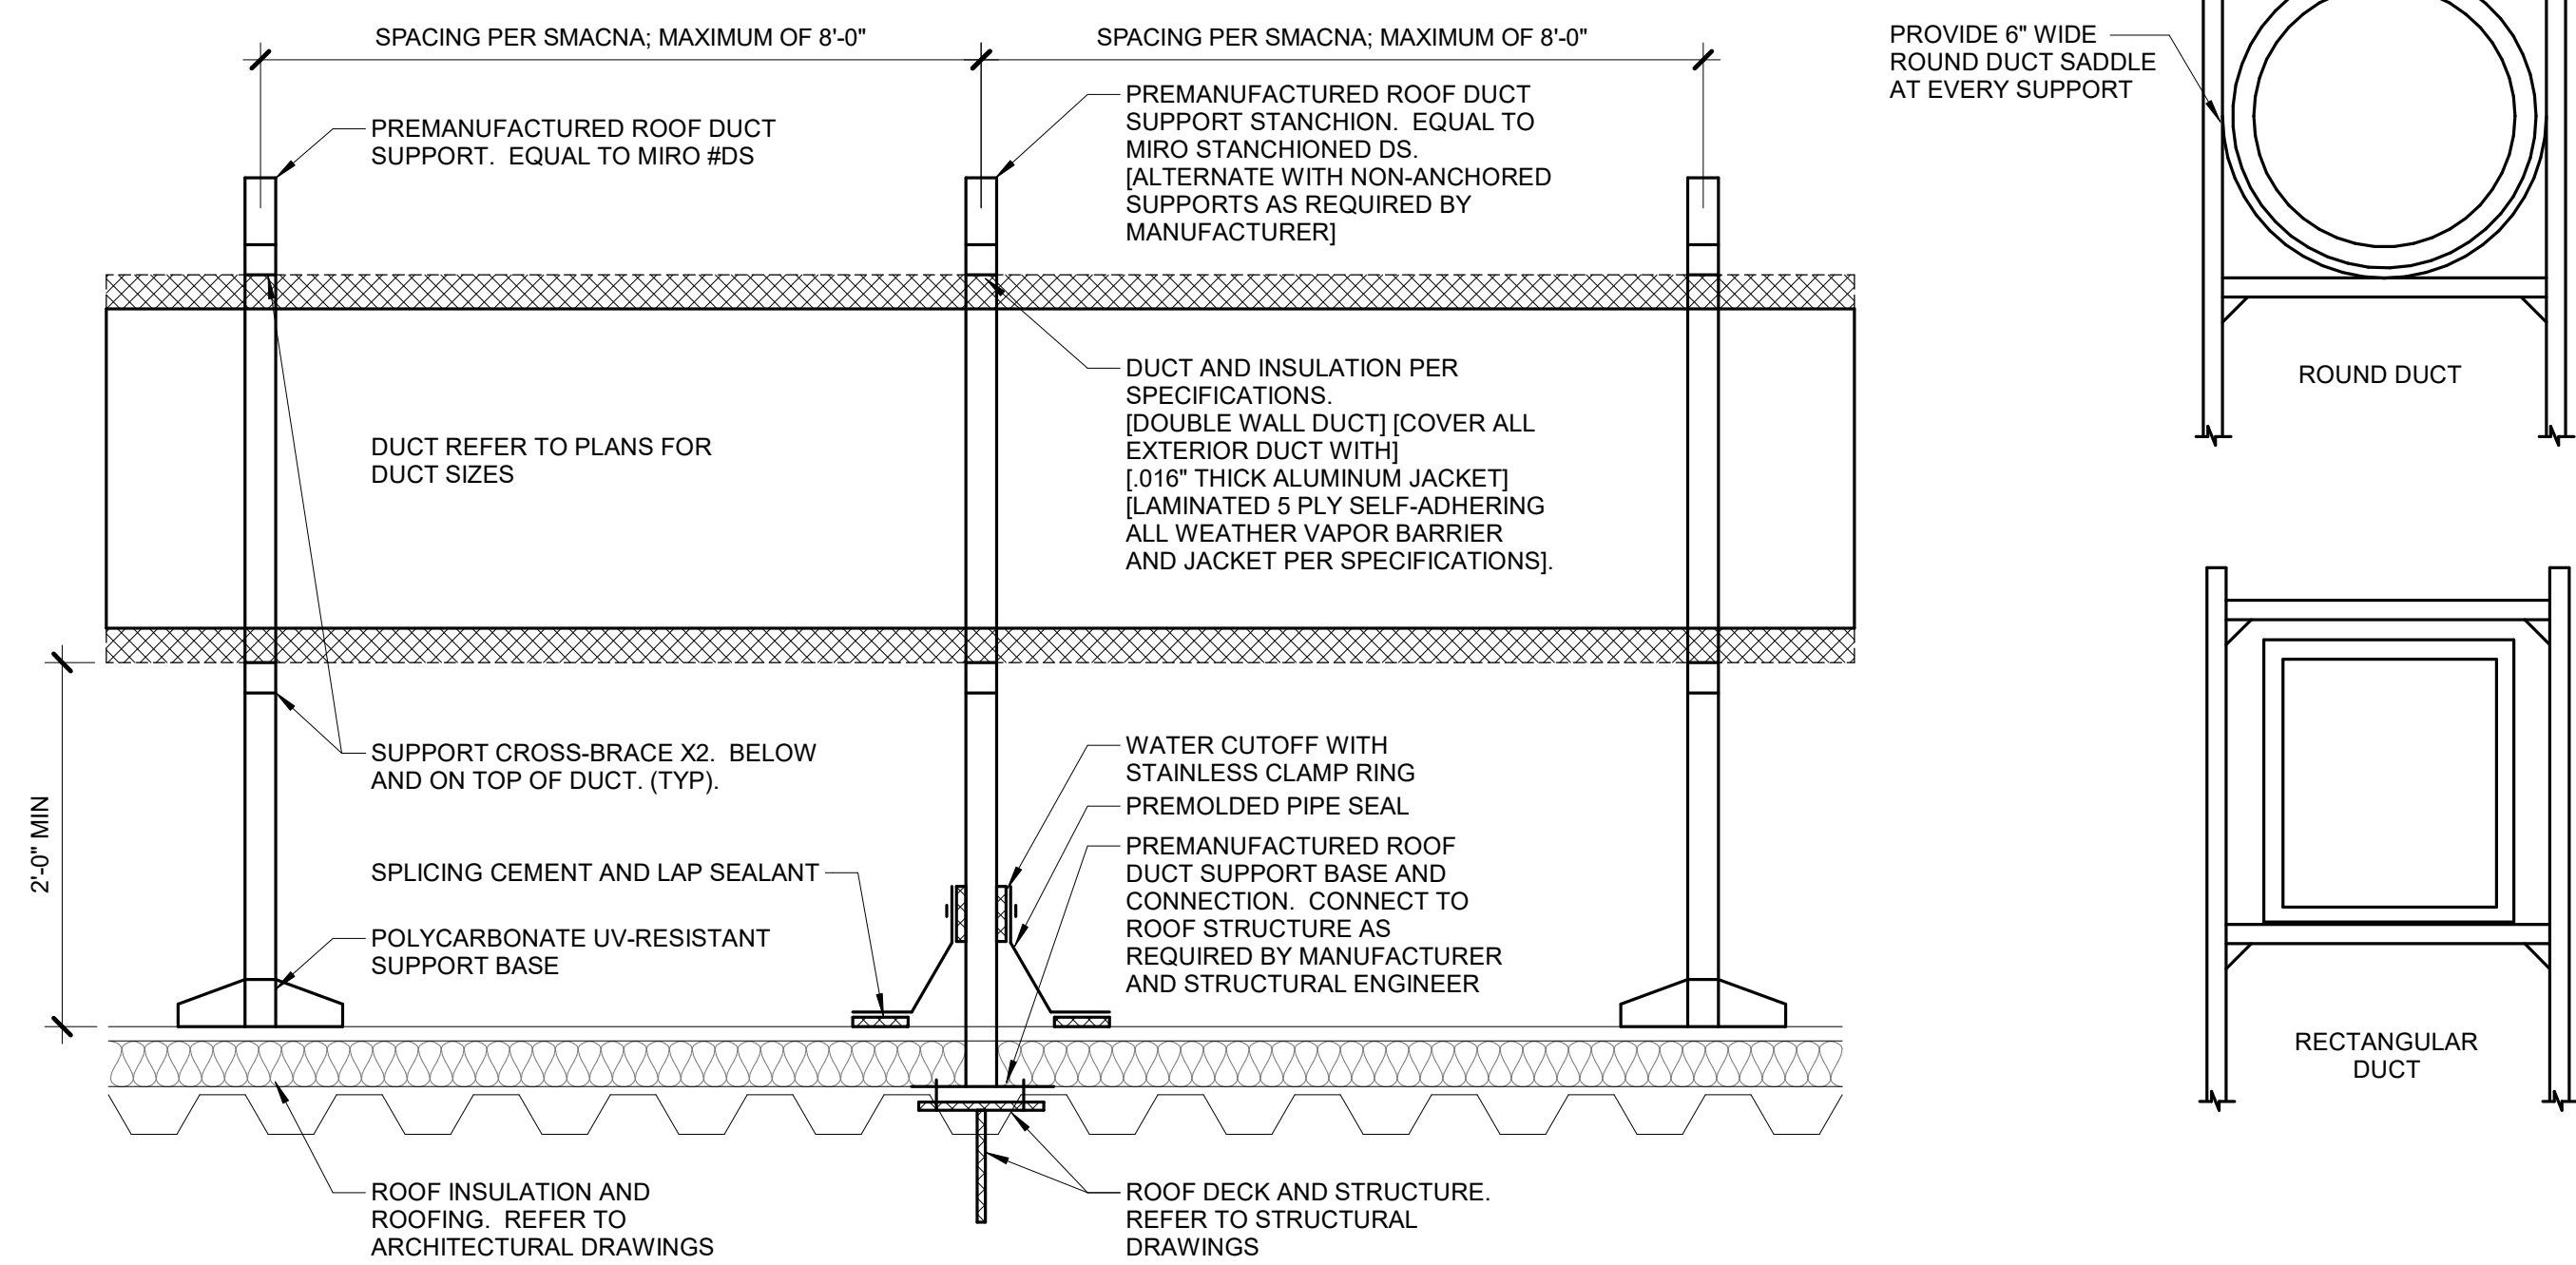


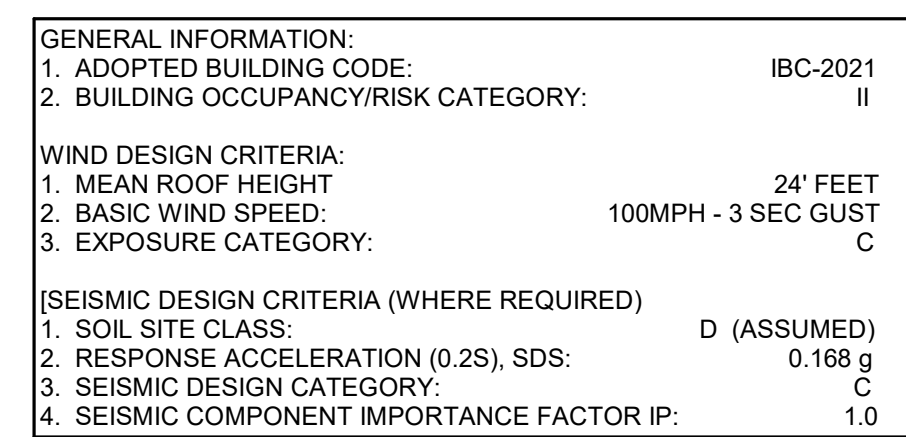


ROOF SUPPORT - EXPOSED DUCT

1 ROOF SUPPORT - EXPOSED DUCT (PREMANUFACTURED)

NO SCALE

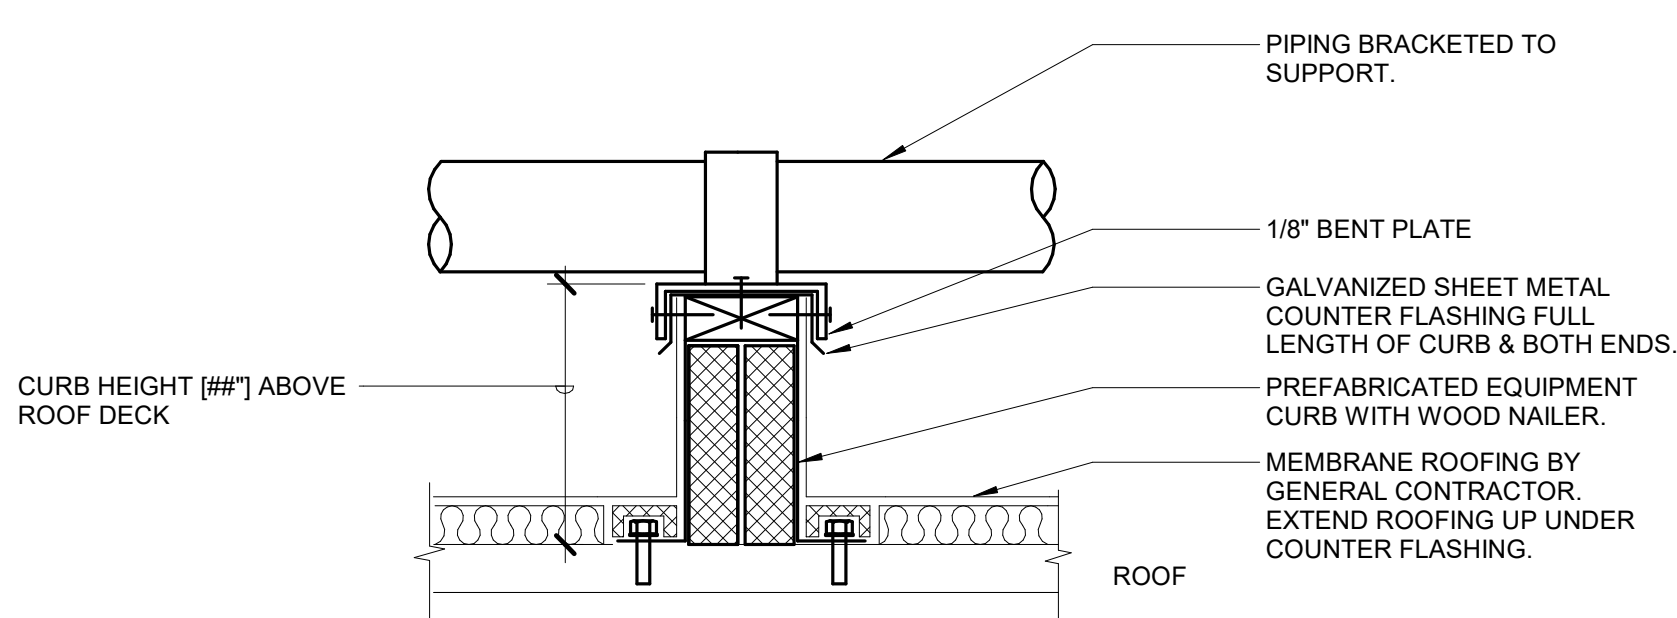


P1100 SERIES PIPE CLAMP			
MODEL	PIPE SIZE	MODEL	PIPE SIZE
P1112SS	3/4"	P1117SS	2"
P1113SS	1"	P1118SS	2-1/2"
P1114SS	1-1/4"	P1119SS	3"
P1115SS	1-1/2"	P1121SS	4"

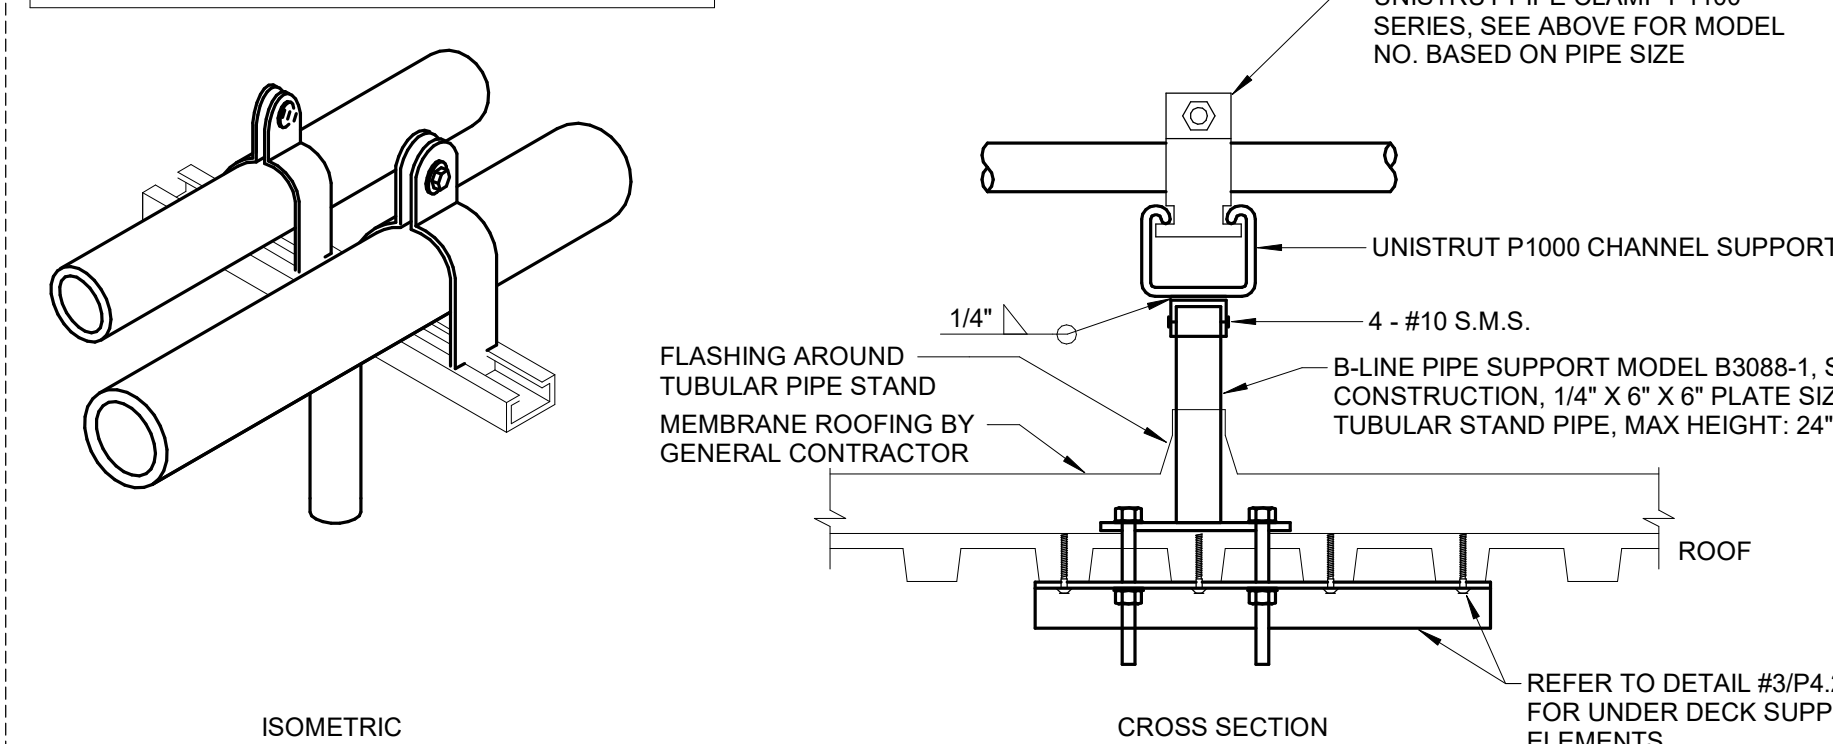


2016 CPC TABLE 313.3 HANGERS AND SUPPORTS		
MATERIALS	TYPES OF JOINTS	HORIZONTAL
CAST-IRON HUBLESS	SHIELDED COUPLING	EVERY OTHER JOINT, UNLESS OVER 4 FEET THEN SUPPORT EACH JOINT
Copper & Copper Alloys	Soldered, Brazed, Threaded, or Mechanical	1 1/2 inches and smaller: 6 feet; 2 inches and larger, 10 feet
Steel Pipe for Gas	Threaded or Welded	1/2 inch: 6 feet; 3/4 inch and 1 inch: 8 feet; 1 1/4 inches and larger, 10 feet


REFER TO CODE SECTION FOR FULL TABLE AND NOTES

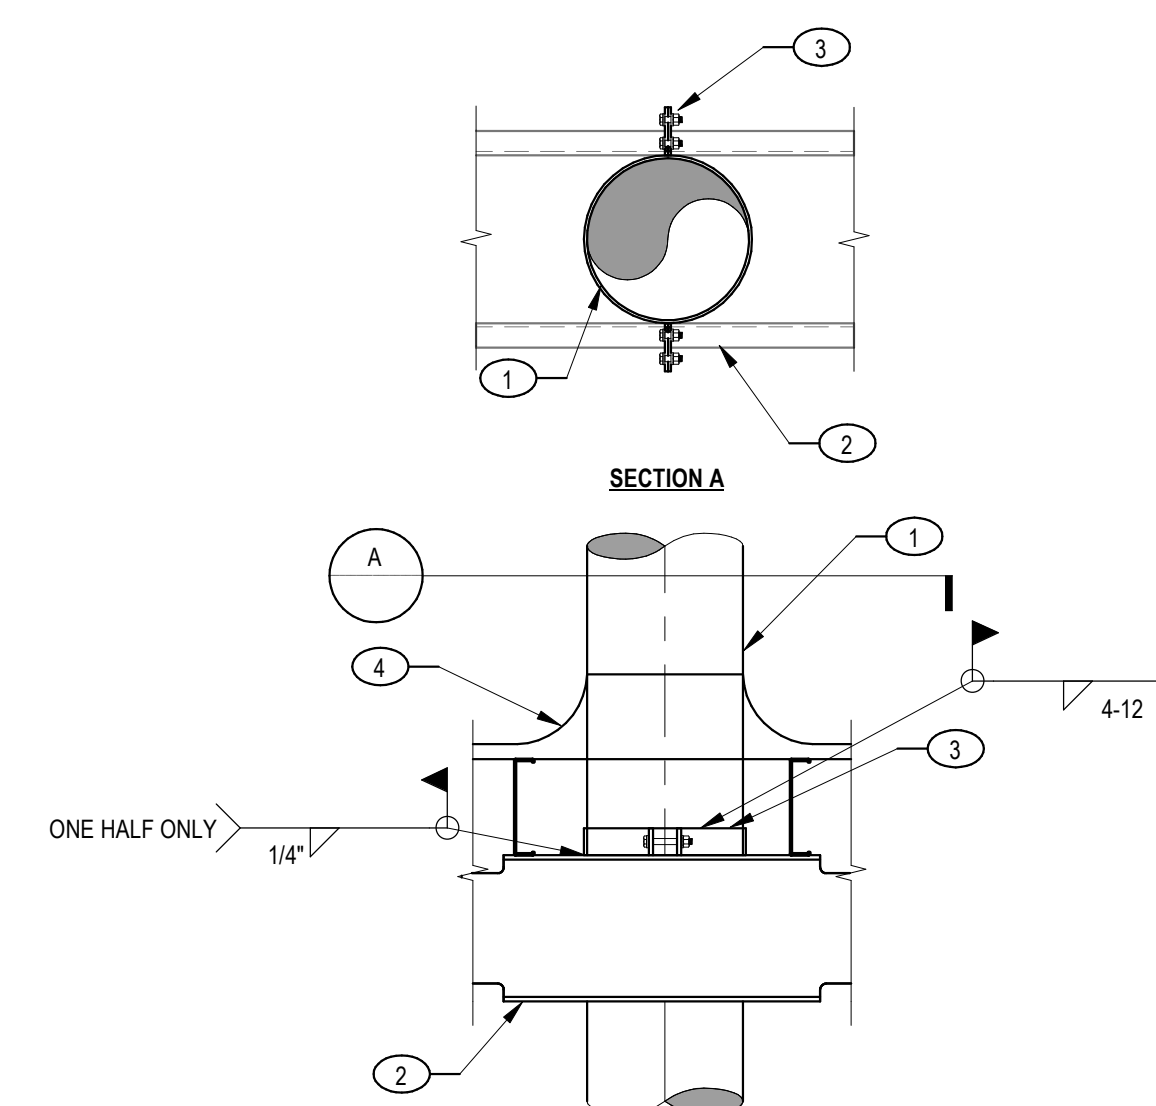

2 DUCT SUPPORT AT ROOF PENETRATION
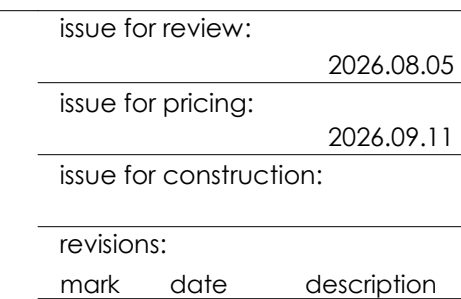
$$3/4" = 1'-0"$$


modus
studio
architecture
+ prototyping
479.455.5577
modusstudio.com
contact@modusstudio.com

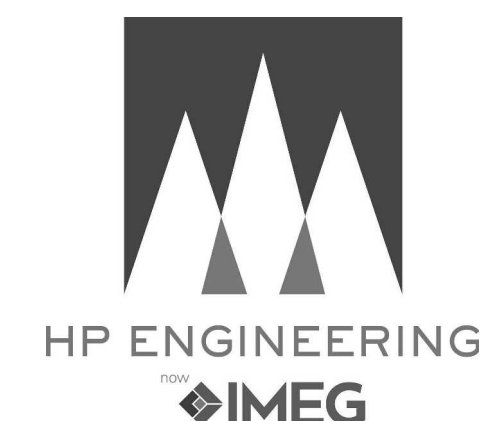

NOT FOR
CONSTRUCTION

WACHTER

REFER TO SHEETS G0.00 - G0.03 FOR ALL
GENERAL NOTES RELATIVE TO THE SCOPE OF
WORK AND TYPES OF DRAWINGS, ELEMENTS
AND INSTRUCTIONS FOUND ON THIS SHEET.

PLEASE REFER TO CONTRACTOR PROVIDED TRADE PACKAGES (DIVISION 00) FOR ALL CONTRACTOR PROJECT REQUIREMENTS. WITHOUT EXCEPTION, **ALL SUBCONTRACTORS ARE RESPONSIBLE FOR REVIEWING ALL CONTRACT DOCUMENTS** (INCLUDING SHEET DRAWINGS, GENERAL NOTES, SPECIFICATIONS ETC.) AS PROVIDED BY THE ARCHITECT OR OTHER CONSULTANT.

contents.

HVAC DETAILS

design.	CD
date.	2026.09.11
project.	25.18



PROJECT #250034

M4.04