

GENERAL NOTES

1 REFER TO SHEET P-001 FOR LEGEND AND NOTES.


KEYED NOTES

- 2" CW PIPING FROM ABANDONED DUCT TO CONNECT TO EXISTING CW MAIN IN BASEMENT MECHANICAL ROOM. FIELD COORDINATE FINAL LOCATION OF PIPE AS NEEDED.
- CONNECT GAS PIPING TO HVAC EQUIPMENT AT THIS LOCATION. PROVIDE ISOLATION VALVE AND DIRT LEG AT THE EQUIPMENT CONNECTION. REFERENCE MANUFACTURER'S CUT SHEET FOR CONNECTION LOCATION PRIOR TO INSTALLATION.
- PROVIDE GAS PRESSURE REGULATOR AT THIS LOCATION. REDUCE PRESSURE DOWN TO 11"WC.
- FEED FLEXIBLE PEX WATER PIPING FROM THIS LOCATION TOWARD MECHANICAL ROOM AND TOWARD COMPUTER ROOM INSIDE ABANDONED DUCT CHASE. ENSURE NEWLY INSTALLED PEX PIPING IS INSULATED TO PROTECT AGAINST CONDENSATION.
- TRANSITION FROM PEX PIPING TO COPPER PIPING WITH APPROPRIATE FITTINGS.
- CW PIPING FROM ABANDONED DUCT TURNS UP IN FURR OUT WALL AND RISES INTO CEILING. KEEP PIPING CONCEALED BEHIND WALL.



PHILANDER
SMITH
UNIVERSITY

M.L. HARRIS
AUDITORIUM
RENOVATION

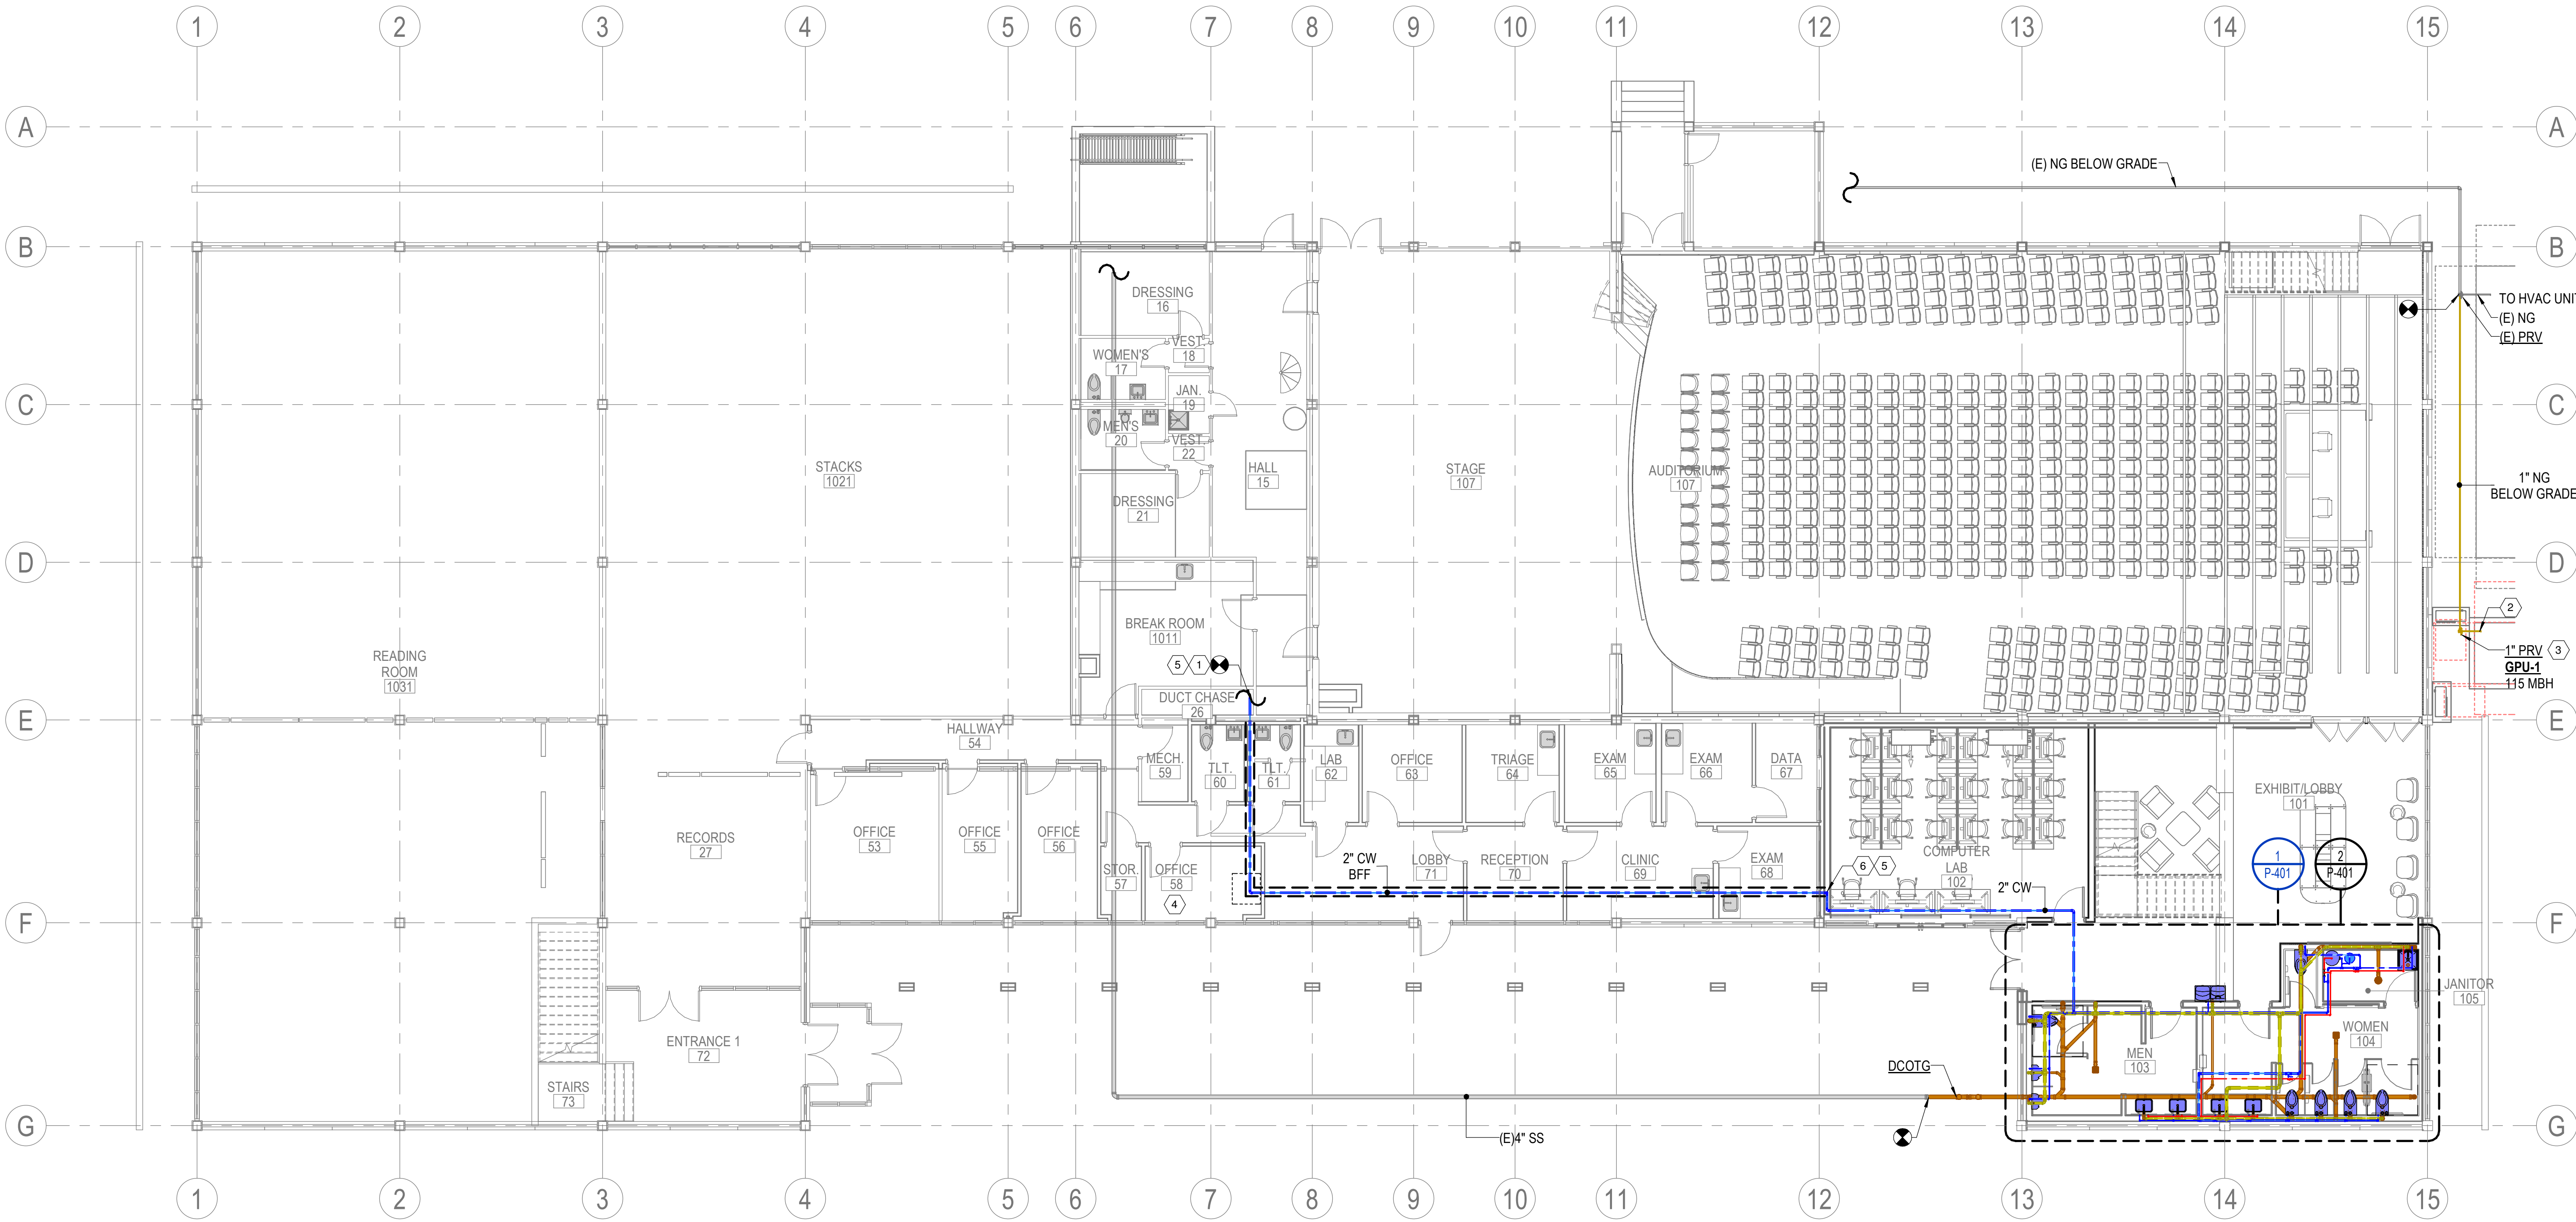

1 FIRST FLOOR PLUMBING PLAN
1/8" = 1'-0"



Volume **VOLUME 1**

CONSTRUCTION
DOCUMENTS

No.	Date	Description



Notes
1. CROMWELL ARCHITECTS ENGINEERS, INC.
ALL RIGHTS RESERVED
2. THIS SHEET DESIGNED FOR COLOR PRINTING.
CRITICAL INFORMATION MAY BE LOST WITH
BLACK AND WHITE PRINTING.

Project Number **2024-060**
Issue Date **09-10-2026**
Sheet Title

FIRST FLOOR PLUMBING
PLAN

Sheet Number

P-101