



PHILANDER  
SMITH  
UNIVERSITY


M.L. HARRIS  
AUDITORIUM  
RENOVATION

GENERAL NOTES


- 1 REFER TO SHEET P-001 FOR LEGEND AND NOTES.

KEYED NOTES

- 1 ALL PIPING ALONG EXTERIOR WALL MUST BE ROUTED BELOW EXISTING WINDOWS.  
2 ALL WATER PIPING INSTALLED ON AN EXTERIOR WALL SHALL HAVE MIN 2" INSULATION TO PREVENT FREEZING PIPES.

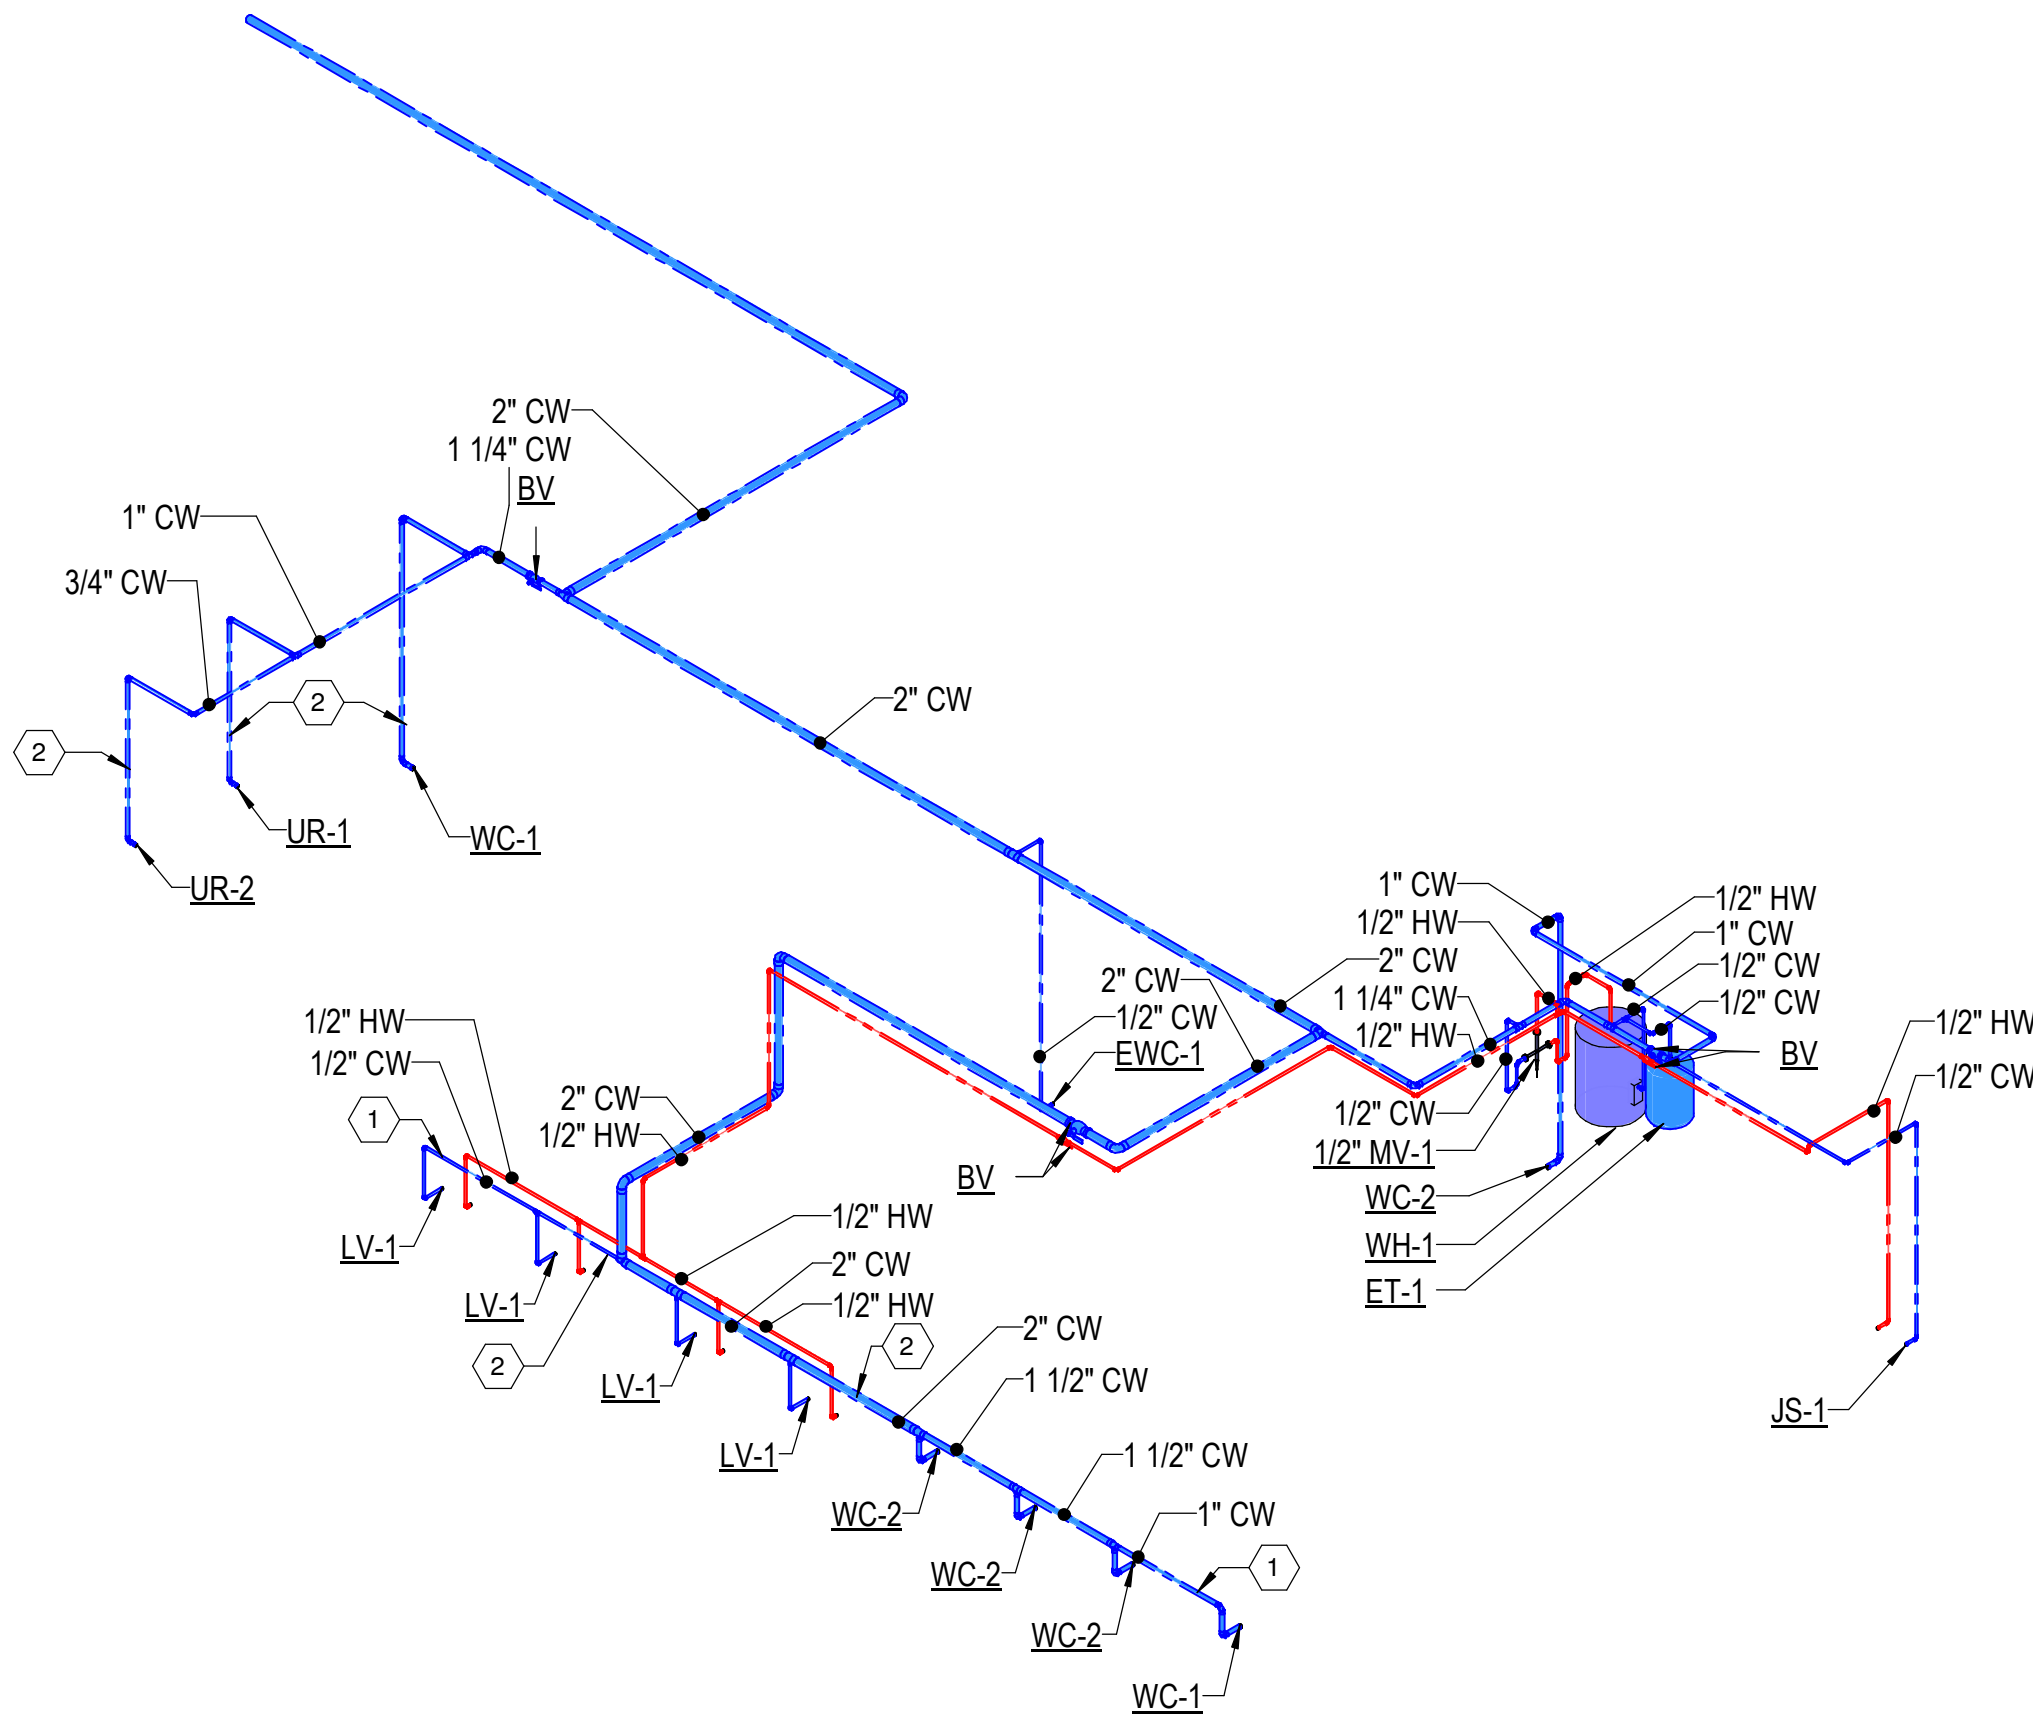

1 ENLARGED DOMESTIC WATER RISER - TOILET ROOMS

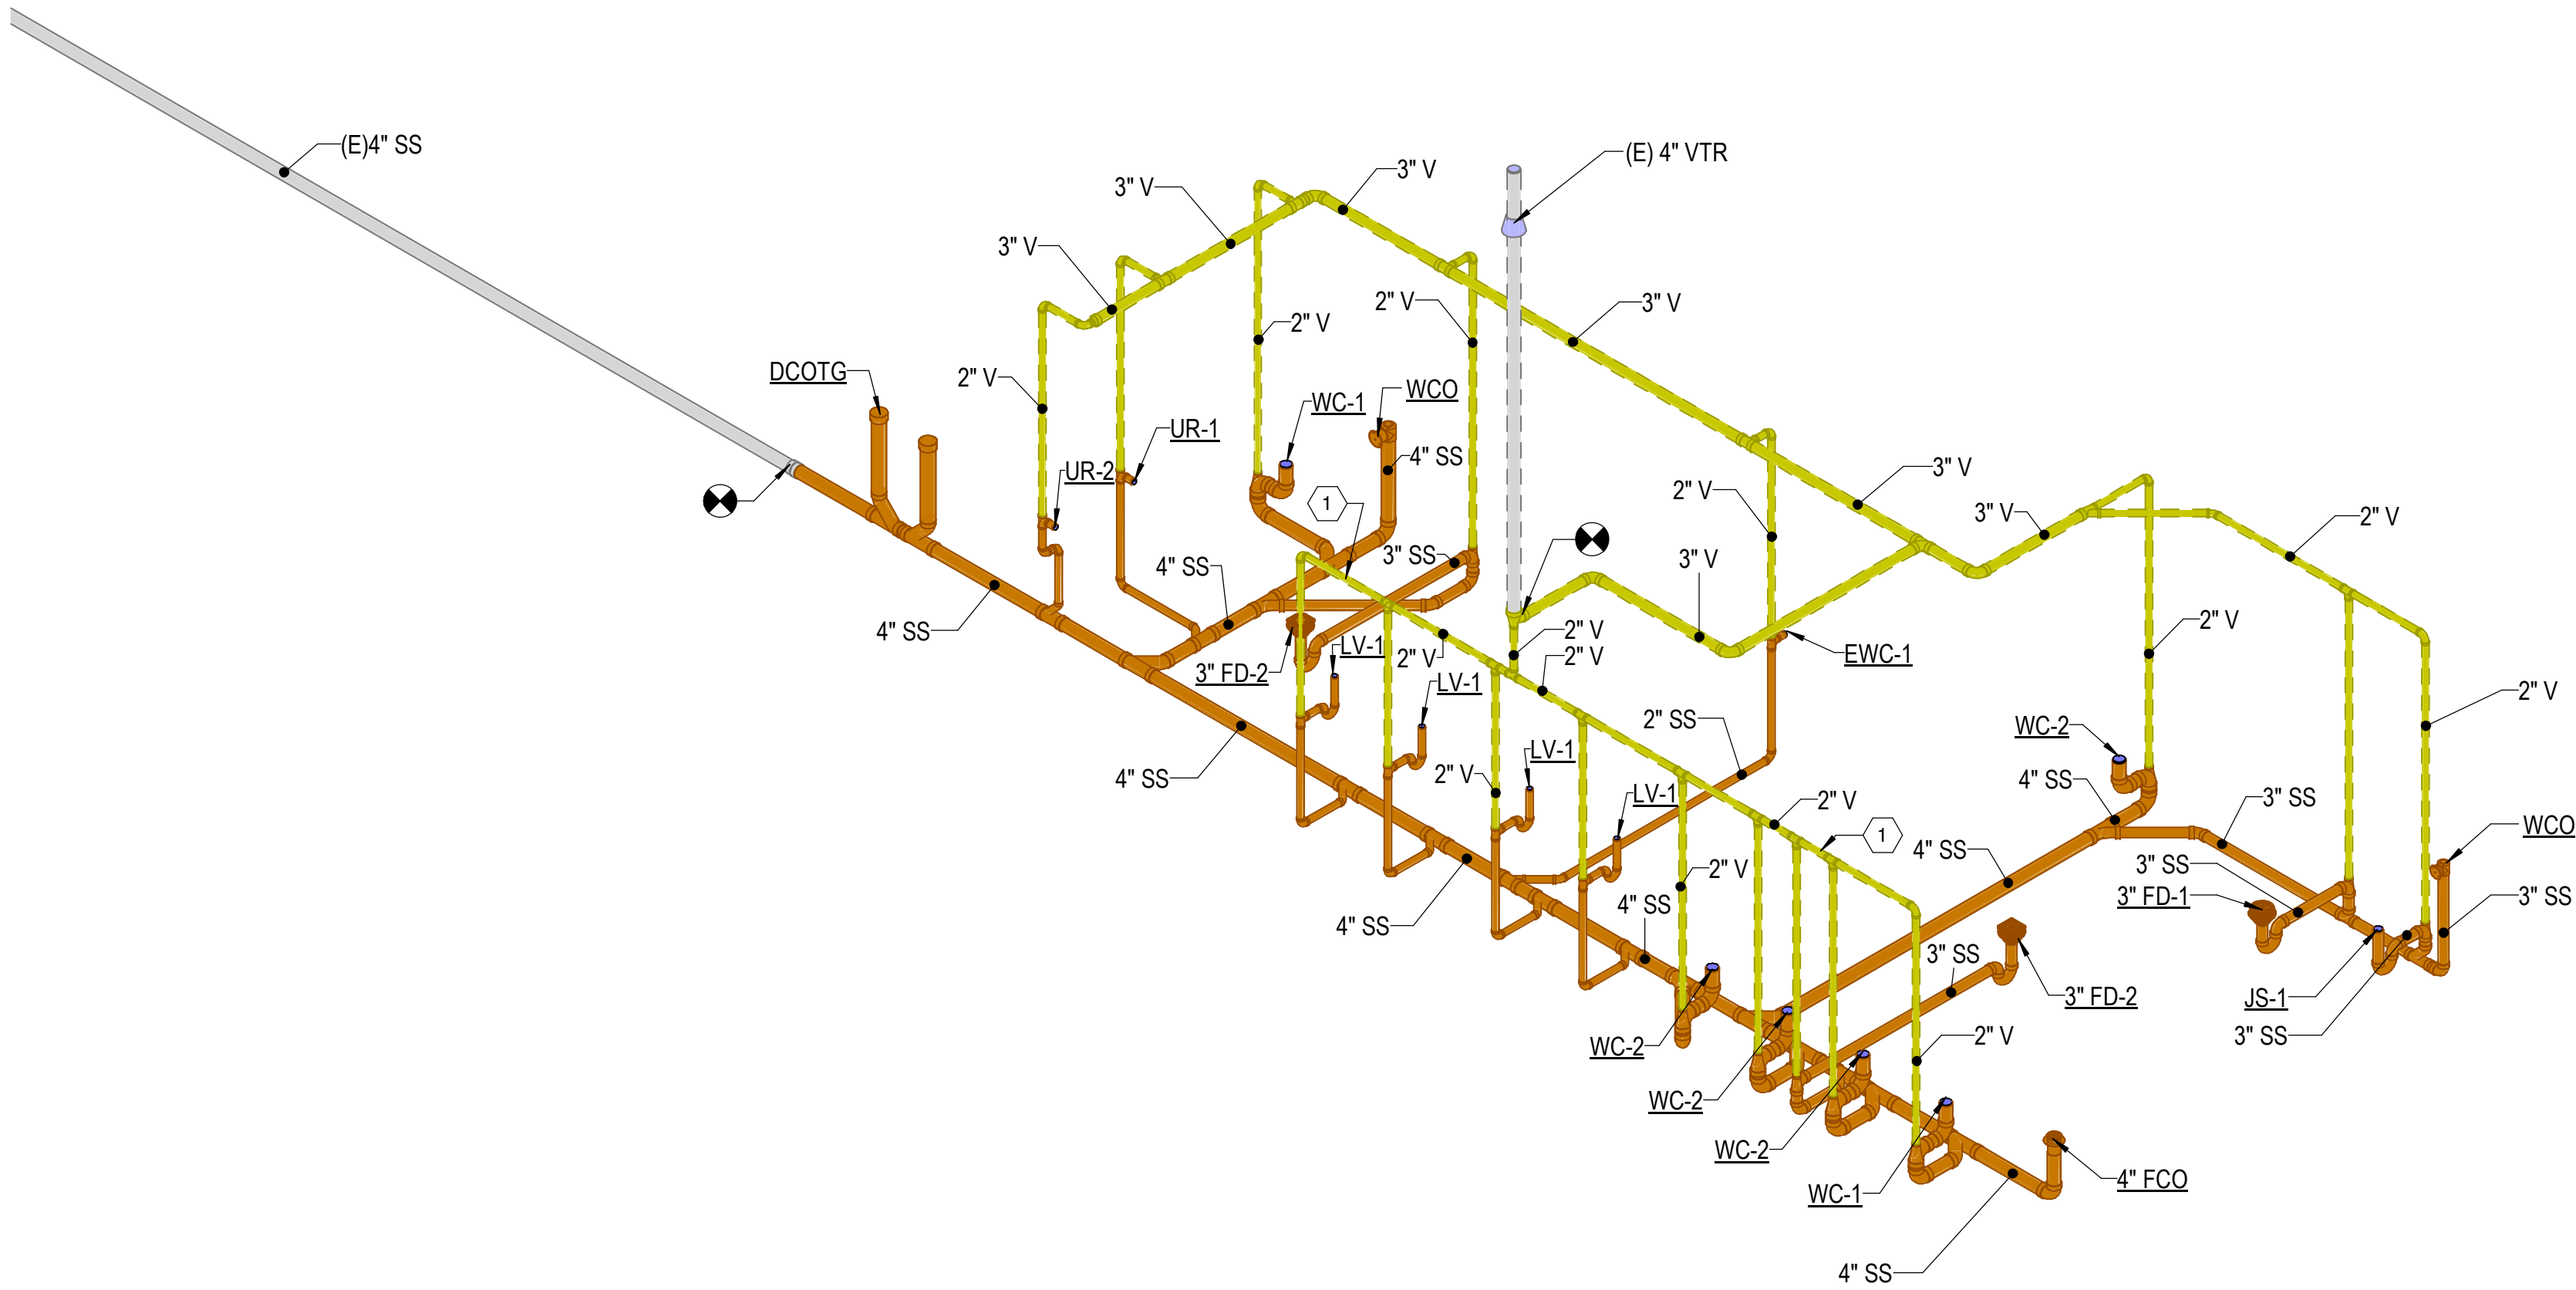

2 ENLARGED DRAIN, WASTE, & VENT RISER - TOILET ROOMS

Volume  
VOLUME 1

CONSTRUCTION  
DOCUMENTS

| Revisions |      |             |
|-----------|------|-------------|
| No.       | Date | Description |
|           |      |             |
|           |      |             |
Stamp

Notes

1. CROMWELL ARCHITECTS ENGINEERS, INC. ALL RIGHTS RESERVED  
2. THIS SHEET DESIGNED FOR COLOR PRINTING. CRITICAL INFORMATION MAY BE LOST WITH BLACK AND WHITE PRINTING.

Project Number 2024-060  
Issue Date 09-10-2026  
Sheet Title PLUMBING RISER  
Sheet Number

P-901