

GENERAL NOTES

1 REFER TO SHEET M-001 FOR MECHANICAL NOTES, ABBREVIATIONS, AND LEGEND SYMBOLS.


KEYED NOTES

- 1 EXISTING SUPPLY AIR DUCT UP. REFER TO M-102 FOR CONTINUATION. FIELD VERIFY EXISTING SIZE AND LOCATION.
- 2 EXISTING RETURN AIR DUCT STUBBED THROUGH WALL INTO RETURN AIR PLENUM. FIELD VERIFY EXISTING SIZE AND LOCATION.
- 3 INSTALL NEW GRILLES WITH RECESSED PLASTER FRAME IN PLACE OF EXISTING GRILLES. FIELD VERIFY EXISTING GRILLE DIMENSIONS PRIOR TO SUBMITTING GRILLES FOR ENGINEER REVIEW.
- 4 MANUAL SWITCH FOR STAGE SMOKE VENT OPENING. PROVIDE ENGRAVED PLASTIC NAMEPLATE ABOVE SWITCH. LOCATE ADJACENT TO FIRE CURTAIN MANUAL RELEASE.



PHILANDER
SMITH
UNIVERSITY

M.L. HARRIS
AUDITORIUM
RENOVATION

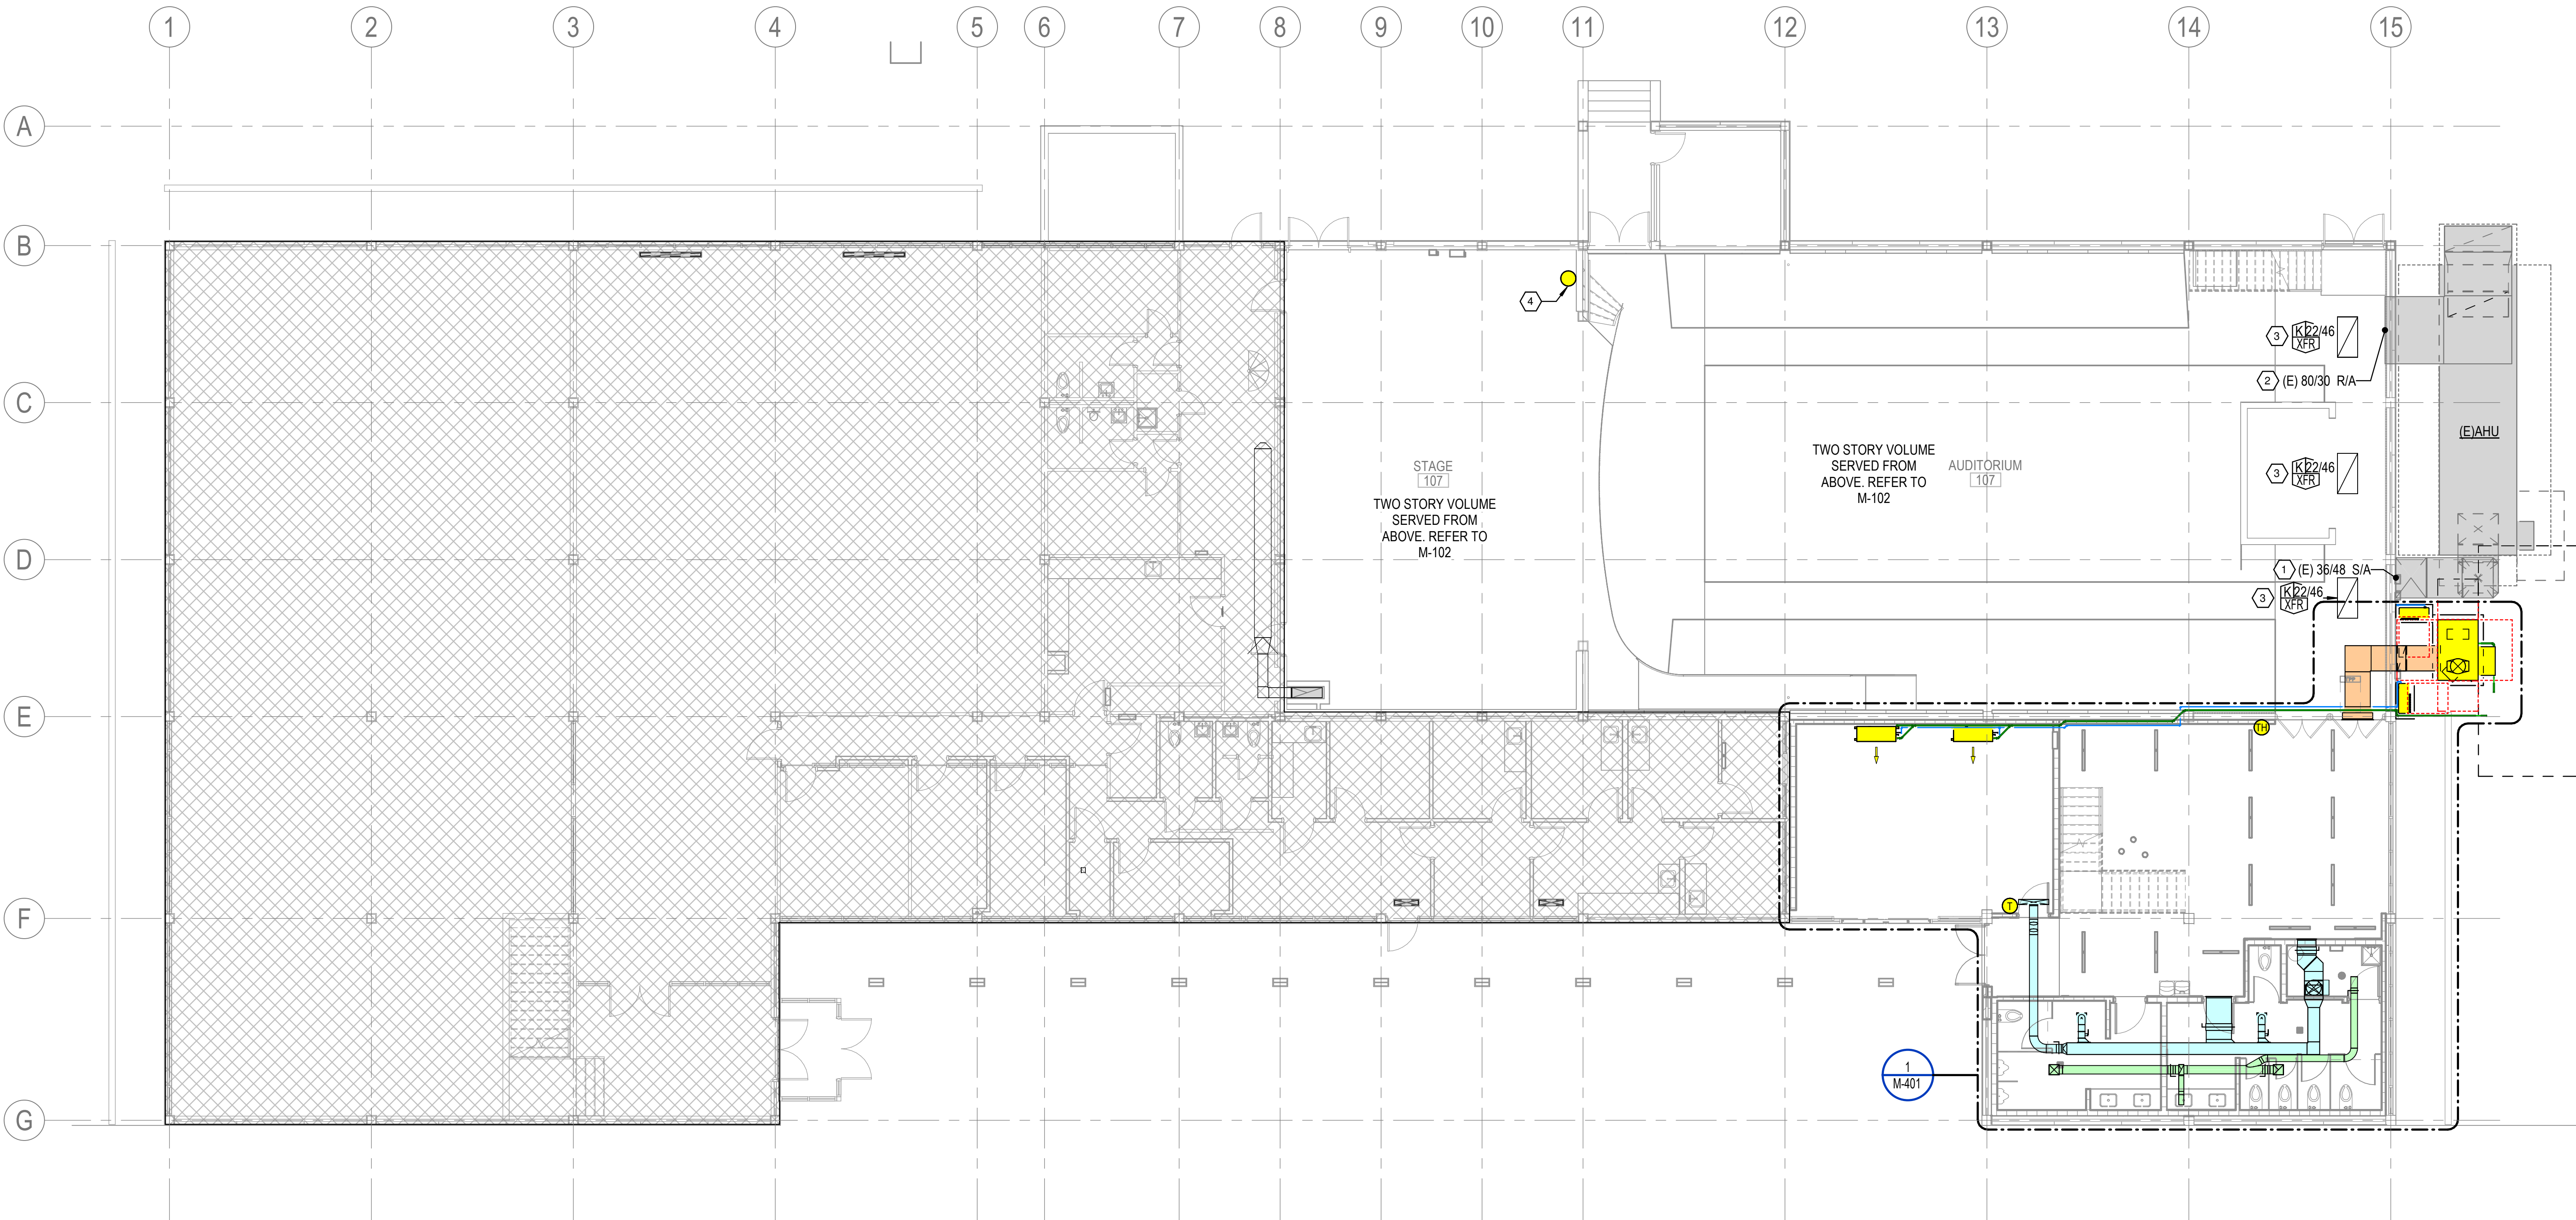


1 FIRST FLOOR MECHANICAL PLAN

Volume VOLUME 1

CONSTRUCTION
DOCUMENTS

Revisions		
No.	Date	Description

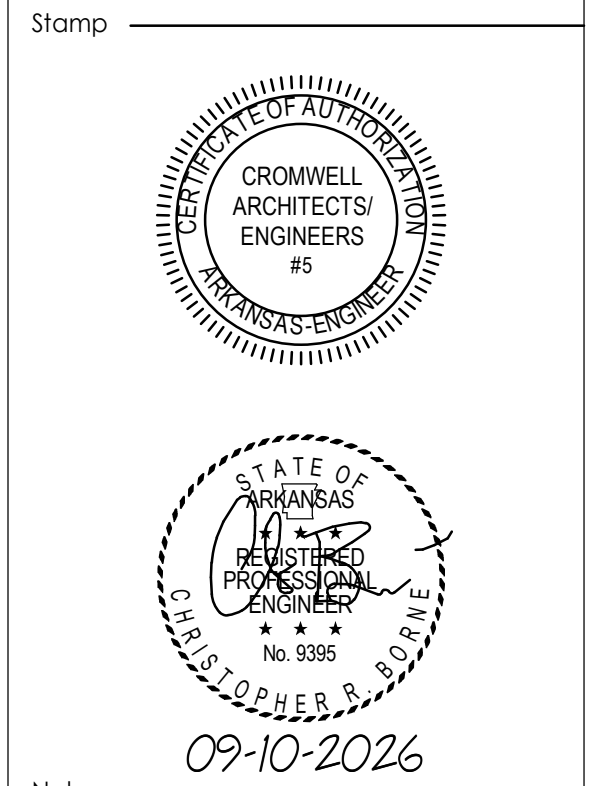

Notes
1. CROMWELL ARCHITECTS ENGINEERS, INC. ALL RIGHTS RESERVED
2. THIS SHEET DESIGNED FOR COLOR PRINTING. CRITICAL INFORMATION MAY BE LOST WITH BLACK AND WHITE PRINTING.

Project Number 2024-060
Issue Date 09-10-2026
Sheet Title

FIRST FLOOR
MECHANICAL PLAN

Sheet Number

M-101