

GENERAL NOTES

1 REFER TO SHEET M-001 FOR MECHANICAL NOTES, ABBREVIATIONS, AND LEGEND SYMBOLS.

KEYED NOTES

- 1 INSTALL NEW DUCT IN EXISTING CHASE EXPOSED BY CEILING REMOVAL. REFER TO ARCHITECTURAL.
- 2 INSTALL DUCT ELBOW TO MAINTAIN CLEARANCE FROM EXISTING LADDER AND SAFETY CAGE. APPROXIMATE LOCATION SHOWN BASED ON RECORD DRAWINGS. CONTRACTOR TO FIELD VERIFY EXACT SIZE AND LOCATION.
- 3 COORDINATE ALL STAGE DUCT AND AIR DEVICE LOCATION WITH THEATER RIGGING, BATTENS, CURTAINS, LIGHTING, ETC. DUCTWORK AND AIR DEVICES ARE TO BE MOVED TO MEET ALL THEATER CLEARANCE REQUIREMENTS.
- 4 PROVIDE 12"x12" ACCESS PANEL FOR BALANCING DAMPER. COORDINATE FINISH WITH ARCHITECT.
- 5 PROVIDE OPTIONAL AIR DEVICE MOUNTED OPPOSED BLADE DAMPER AT THIS GRILLE.



PHILANDER
SMITH
UNIVERSITY

M.L. HARRIS
AUDITORIUM
RENOVATION

Volume **VOLUME 1**

CONSTRUCTION
DOCUMENTS

Revisions	No.	Date	Description

Stamp

CROMWELL ARCHITECTS/ENGINEERS #5

STATE OF ARKANSAS PROFESSIONAL ENGINEER No. 9395

09-10-2026

Notes

1. CROMWELL ARCHITECTS ENGINEERS, INC. ALL RIGHTS RESERVED

2. THIS SHEET DESIGNED FOR COLOR PRINTING. CRITICAL INFORMATION MAY BE LOST WITH BLACK AND WHITE PRINTING.

Project Number **2024-060**


Issue Date **09-10-2026**

Sheet Title

SECOND FLOOR
MECHANICAL PLAN

Sheet Number

M-102

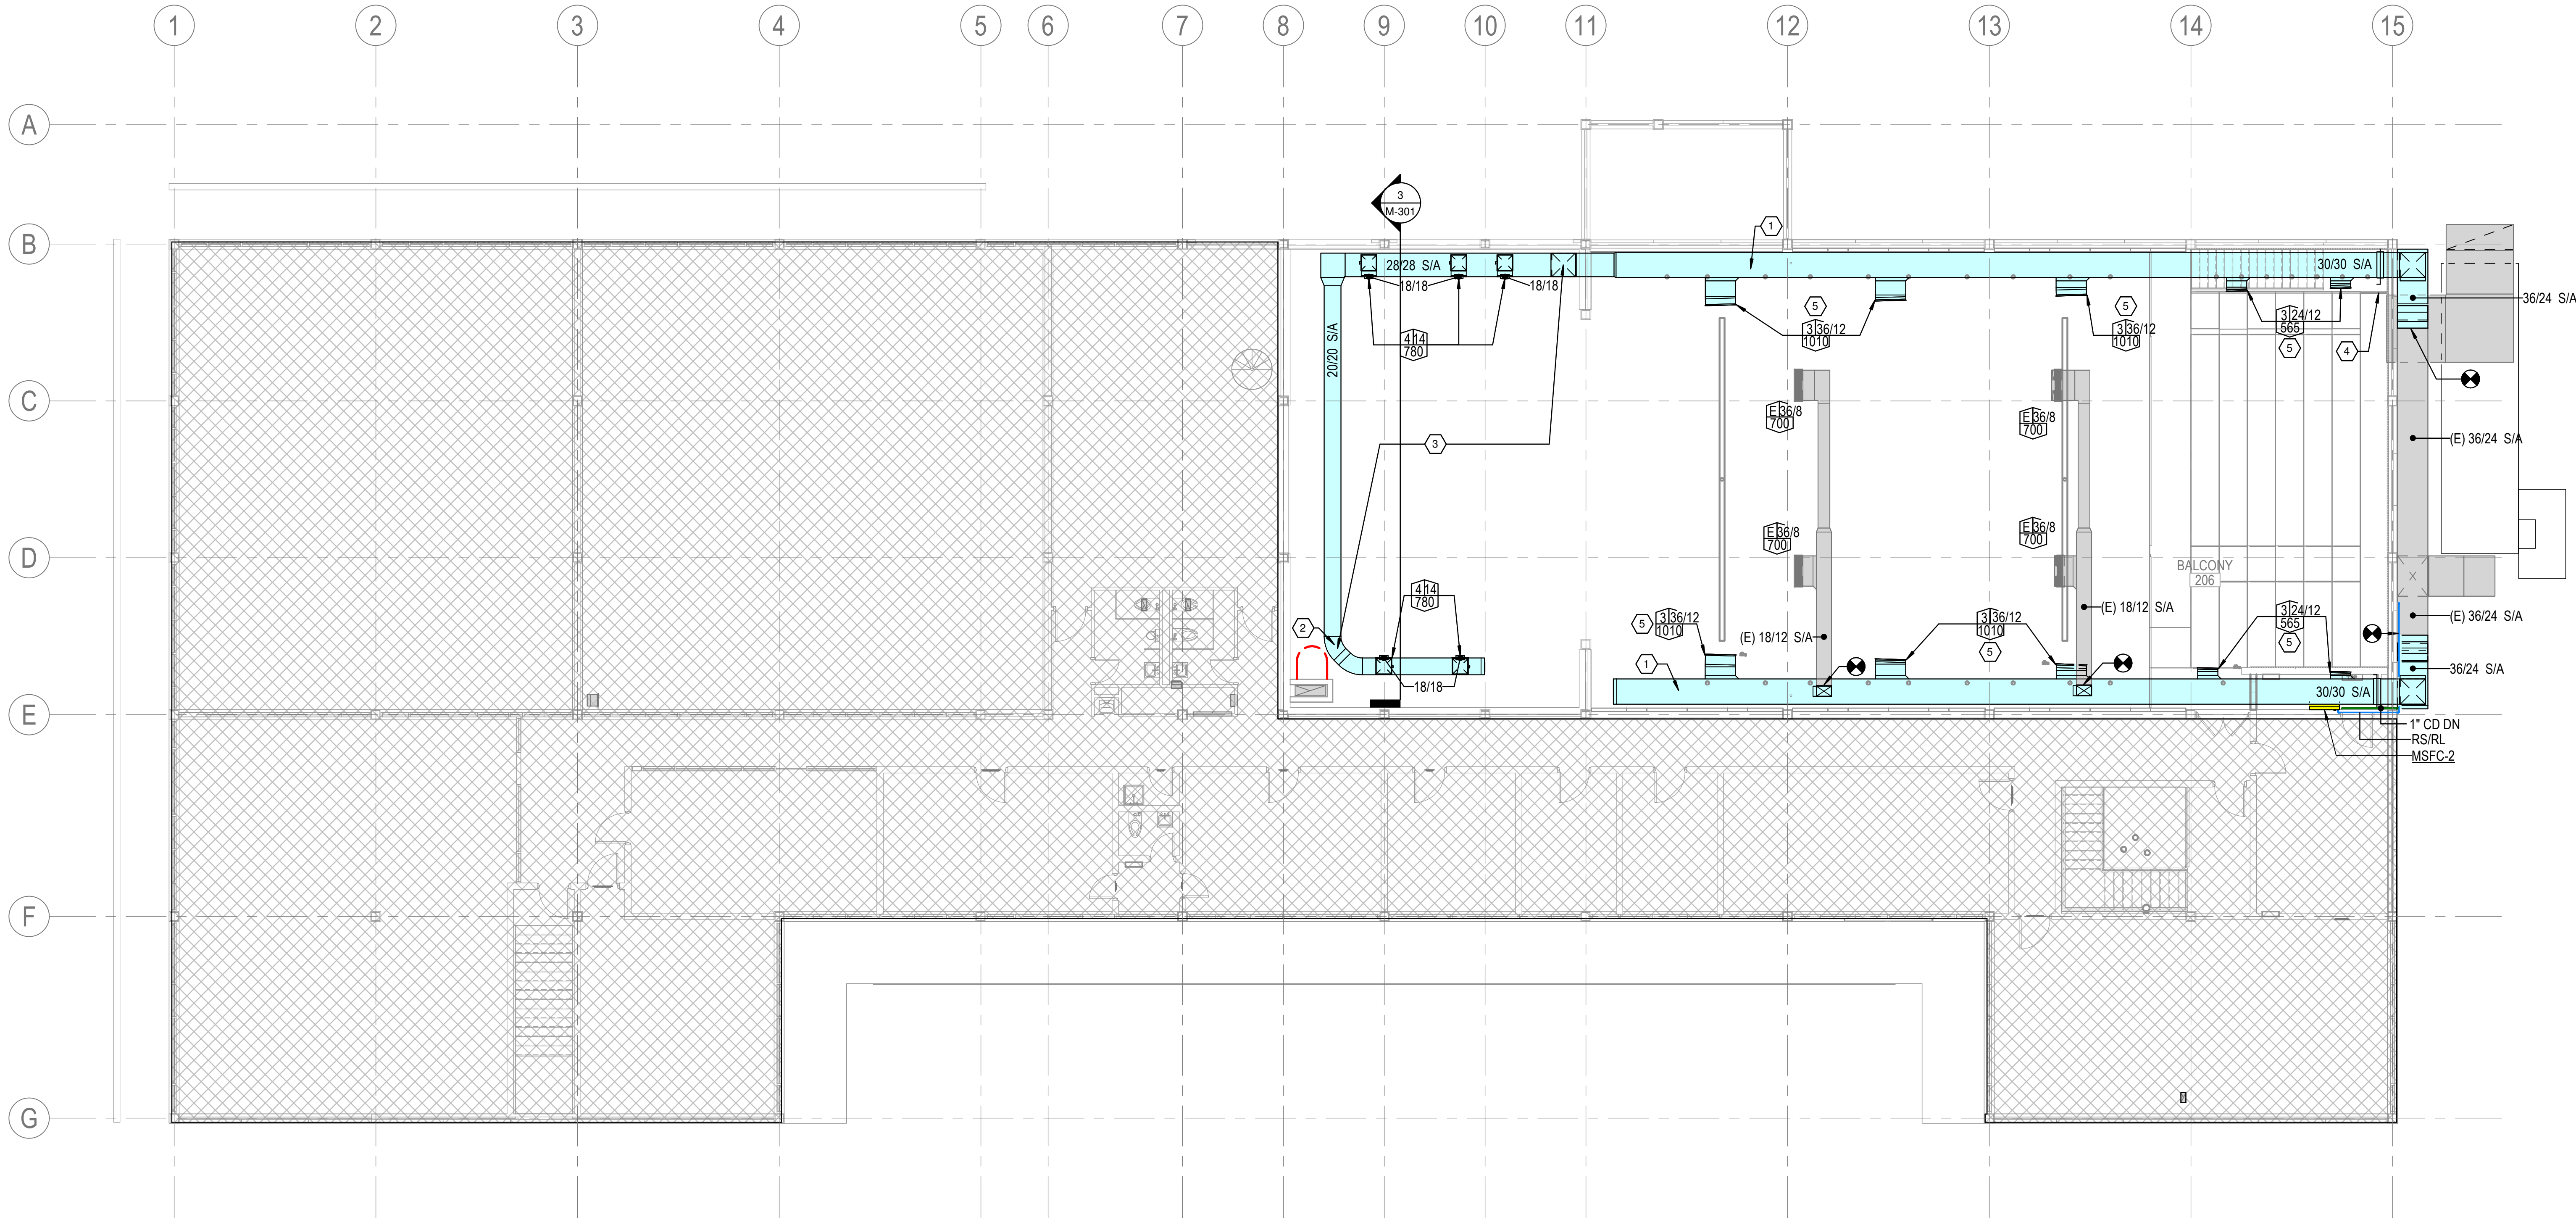

1 SECOND FLOOR MECHANICAL PLAN
1/8" = 1'-0"

