



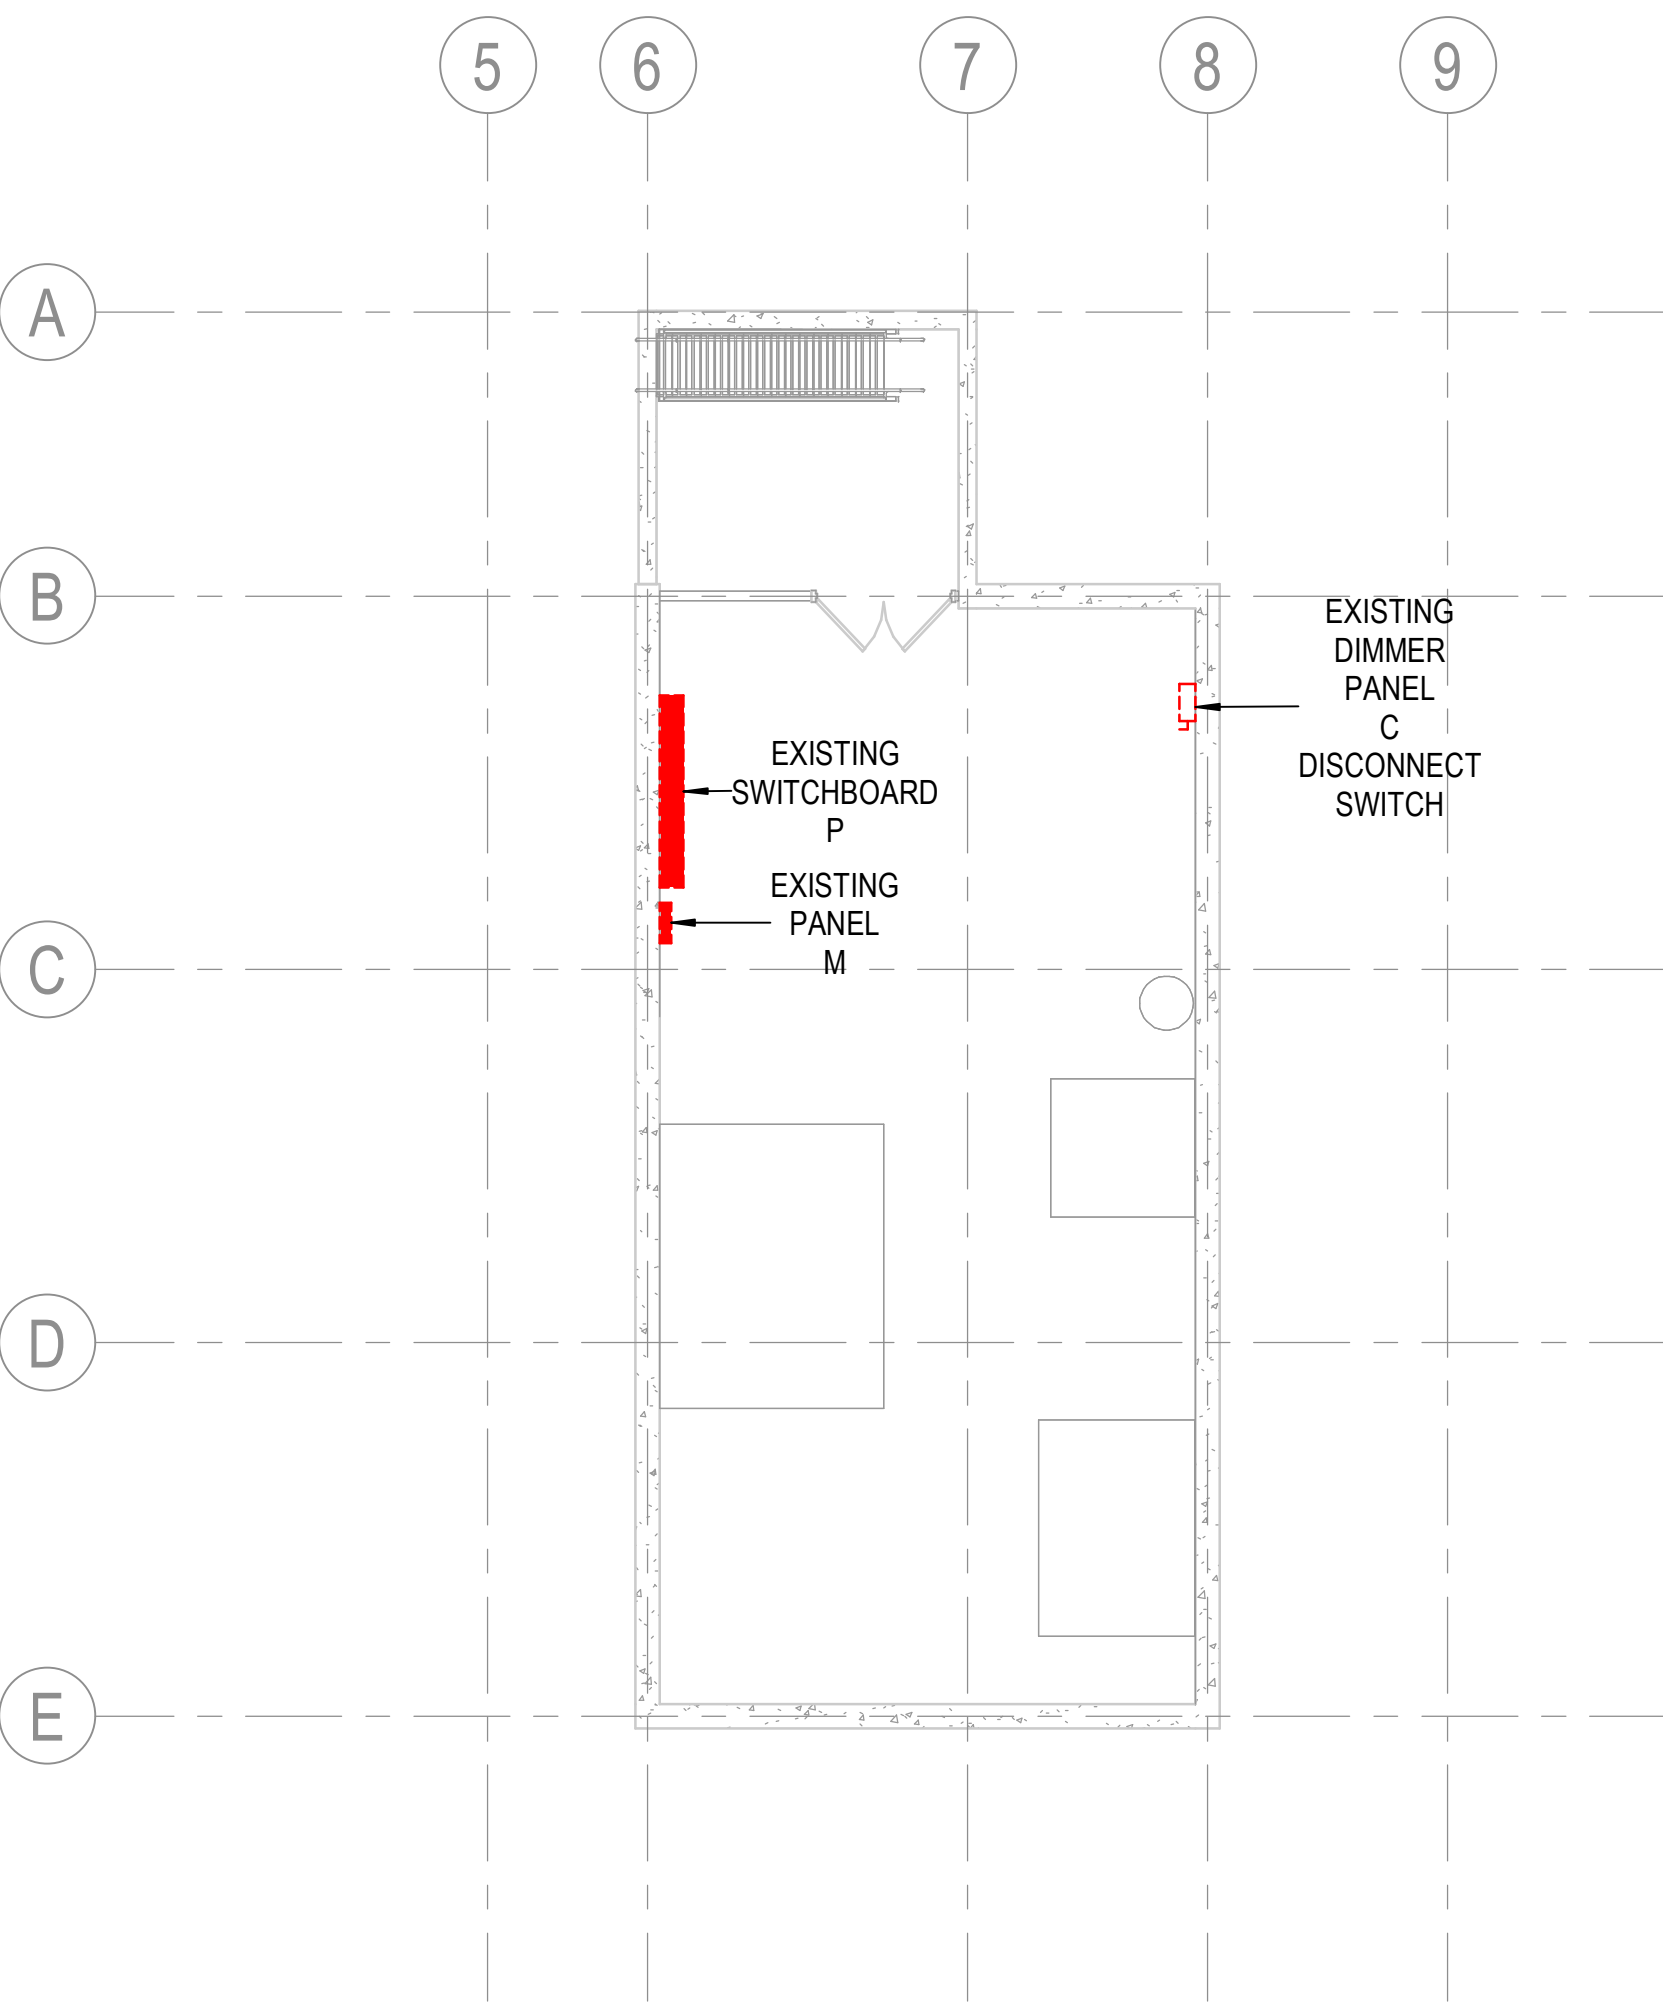

1 BASEMENT ELECTRICAL DEMOLITION PLAN
1/8" = 1'-0"
SCALE : 1/8" = 1'-0"

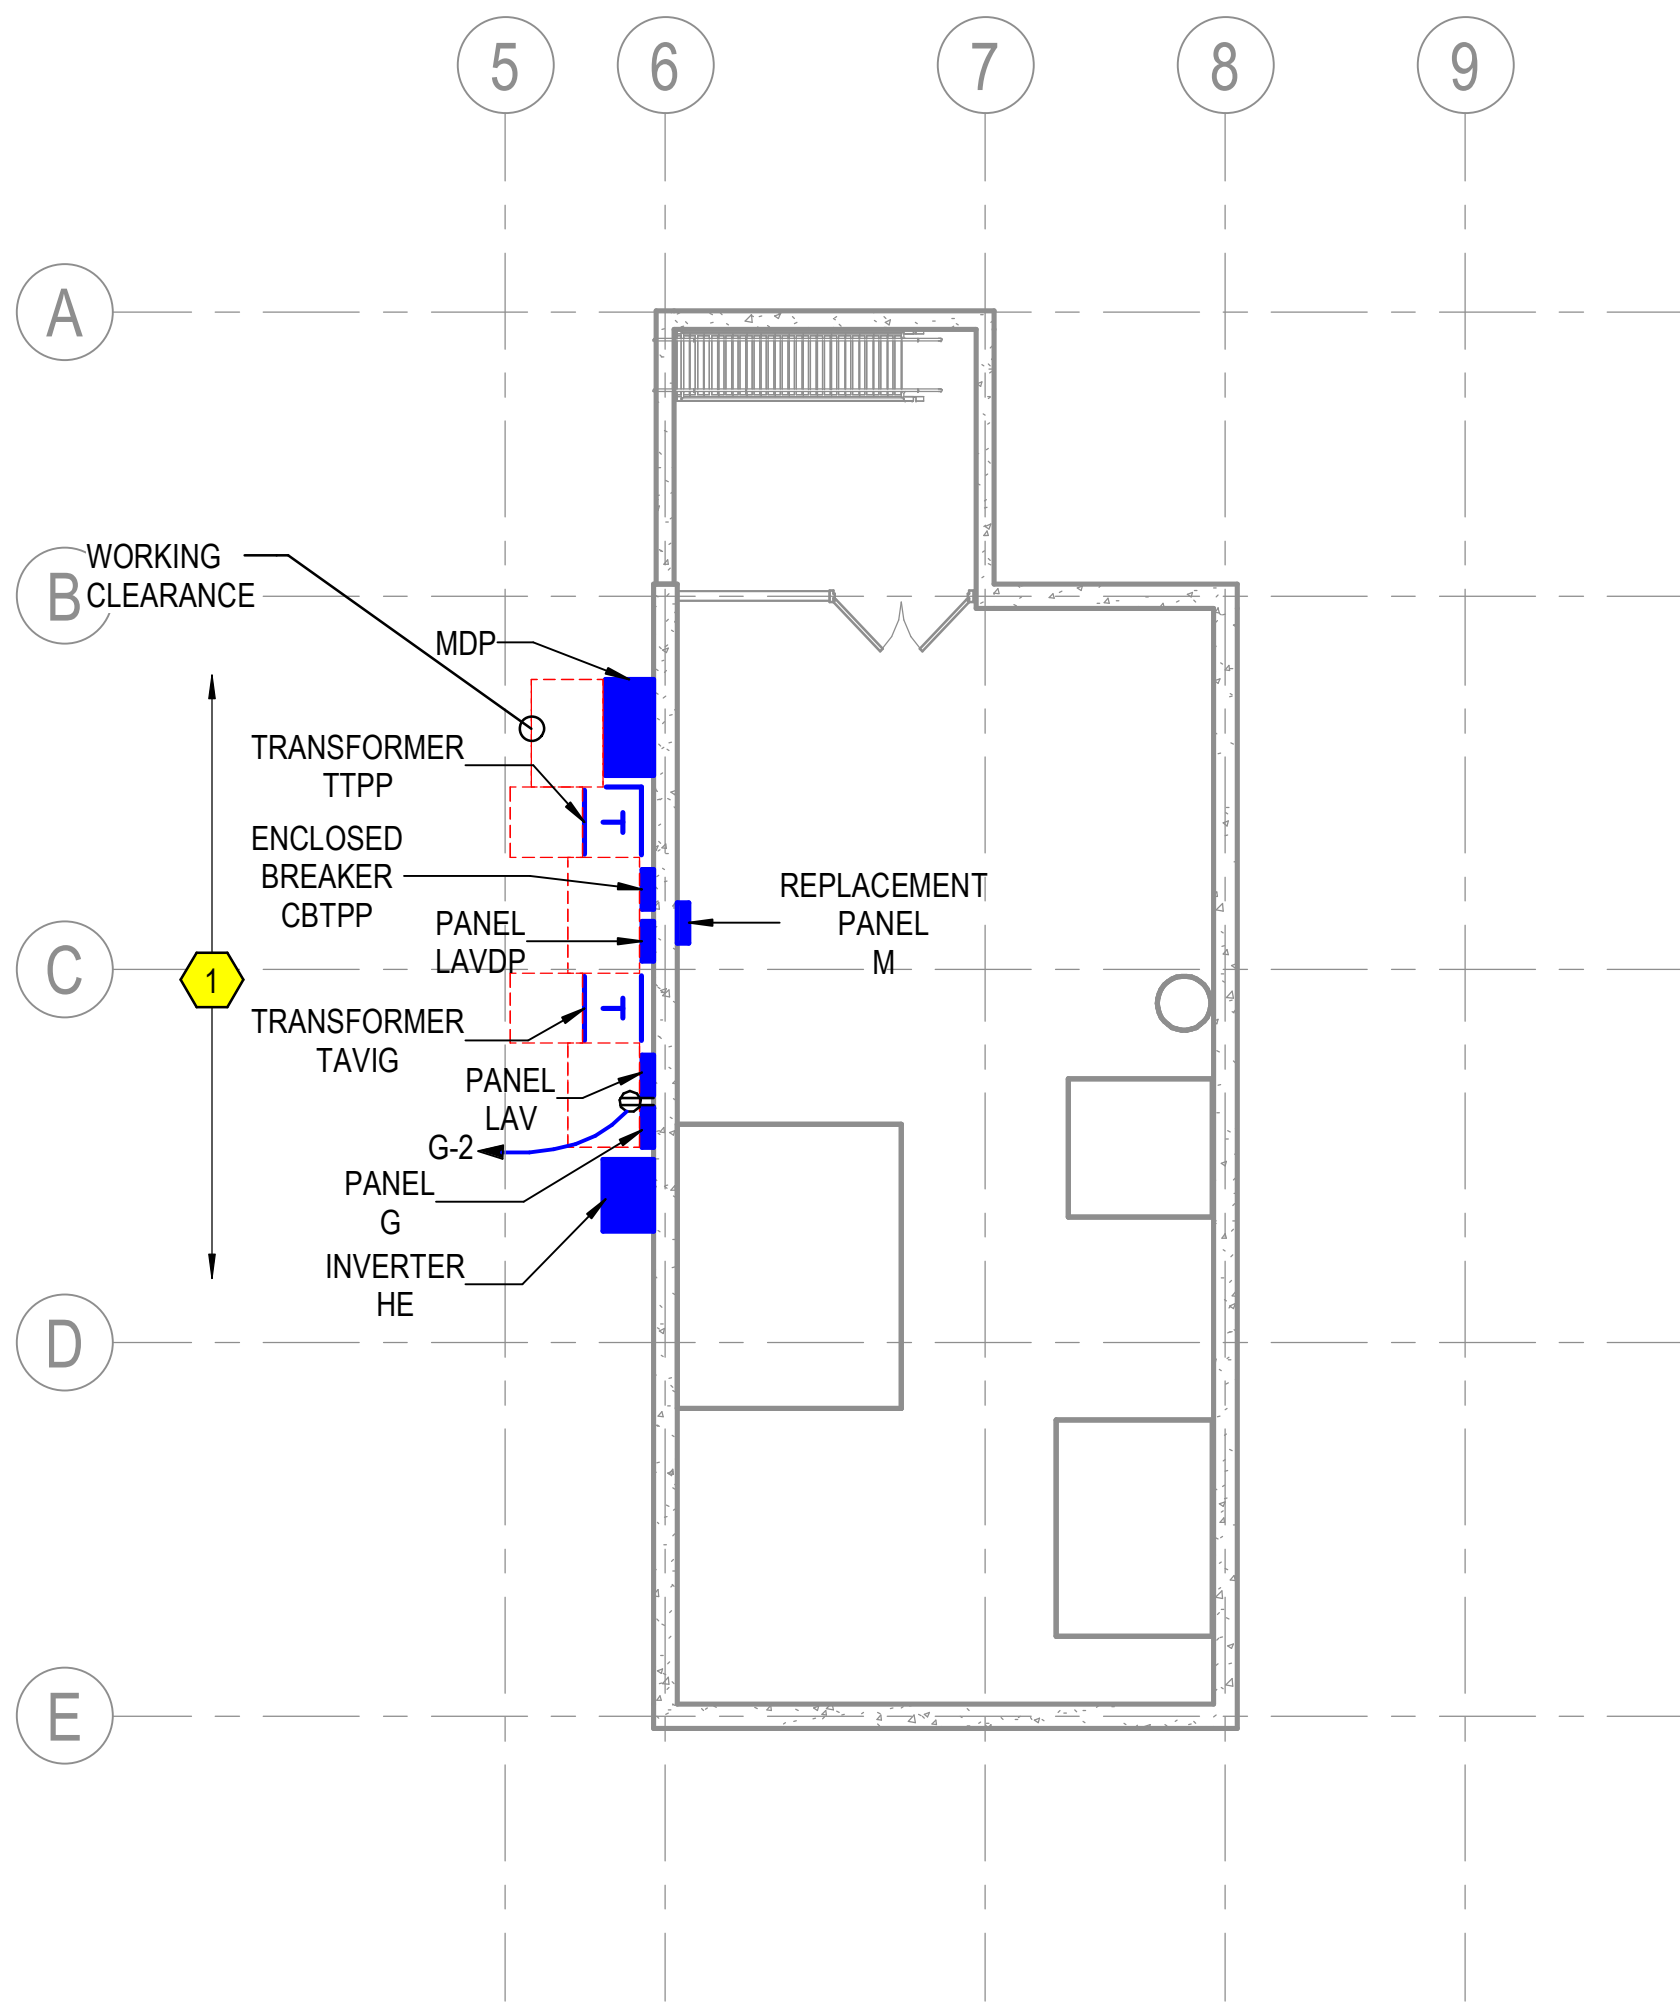

2 BASEMENT POWER PLAN
1/8" = 1'-0"
SCALE : 1/8" = 1'-0"

KEYED NOTES:

- 1 EQUIPMENT LAYOUT TO BE DETERMINED. EXISTING FASTENED-IN-PLACE SHELVING SUPPORTS THE SLAB ABOVE. DO NOT REMOVE SHELVING.




**PHILANDER
SMITH
UNIVERSITY**

**M.L. HARRIS
AUDITORIUM
RENOVATION**

Volume **VOLUME 1**

Design Phase
**CONSTRUCTION
DOCUMENTS**

Revisions	No.	Date	Description

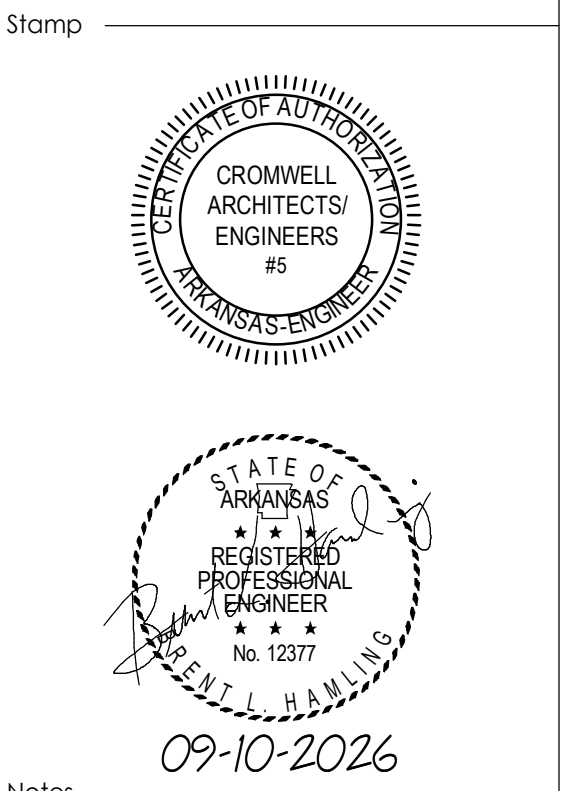

- Notes
1. CROMWELL ARCHITECTS ENGINEERS, INC. ALL RIGHTS RESERVED
 2. THIS SHEET DESIGNED FOR COLOR PRINTING. CRITICAL INFORMATION MAY BE LOST WITH BLACK AND WHITE PRINTING.

Project Number **2024-060**
Issue Date **09-10-2026**
Sheet Title

**BASEMENT ELECTRICAL
PLANS**

Sheet Number
E-100