



PHILANDER
SMITH
UNIVERSITY


M.L. HARRIS
AUDITORIUM
RENOVATION

GENERAL NOTES:


- A. IN STAIR 50, WHERE PORTIONS OF EXPOSED CONDUIT ARE UNAVOIDABLE, PAINT CONDUIT TO MATCH THE MOUNTING SURFACE. ROUTE CONDUIT IN CORNERS WHERE FEASIBLE.
- B. SEE NOTES ON EL101.

KEYED NOTES:

- 1 TO FIXTURE TYPE B1E BELOW. STARWELL FIXTURES ON THIS CIRCUIT ARE NOT TO BE ENERGIZED AT ALL TIMES. REMOVE FROM EXISTING LIGHTING CONTROLS. MAINTAIN CONTROLS FOR OTHER EXISTING LIGHTING WHICH IS TO REMAIN.
- 2 TO FIXTURE TYPE B1 BELOW.
- 3 STAIR RAILING EXTENDS TO THE 2ND FLOOR. CENTER THE LIGHT FIXTURE BETWEEN THE VERTICAL MEMBERS OF THE RAILING.
- 4 CONTROLLED VIA RELAY IN MZC-1. SEE SHULER SHOOK DRAWING SKE 011 AND TL 011.
- 5 DISCONNECT AND REMOVE EXISTING CIRCUIT SERVING LIGHT FIXTURES ABOVE GRIDIRON. RECONNECT EXISTING LIGHT FIXTURES AS INDICATED.
- 6 CIRCUIT IS ALSO FED BY INVERTER VIA ALCR. SEE DETAIL 9/E-501.
- 7 CONNECT TO EXISTING LIGHTING CIRCUIT AND CONTROLS IN BROADCAST ROOM.

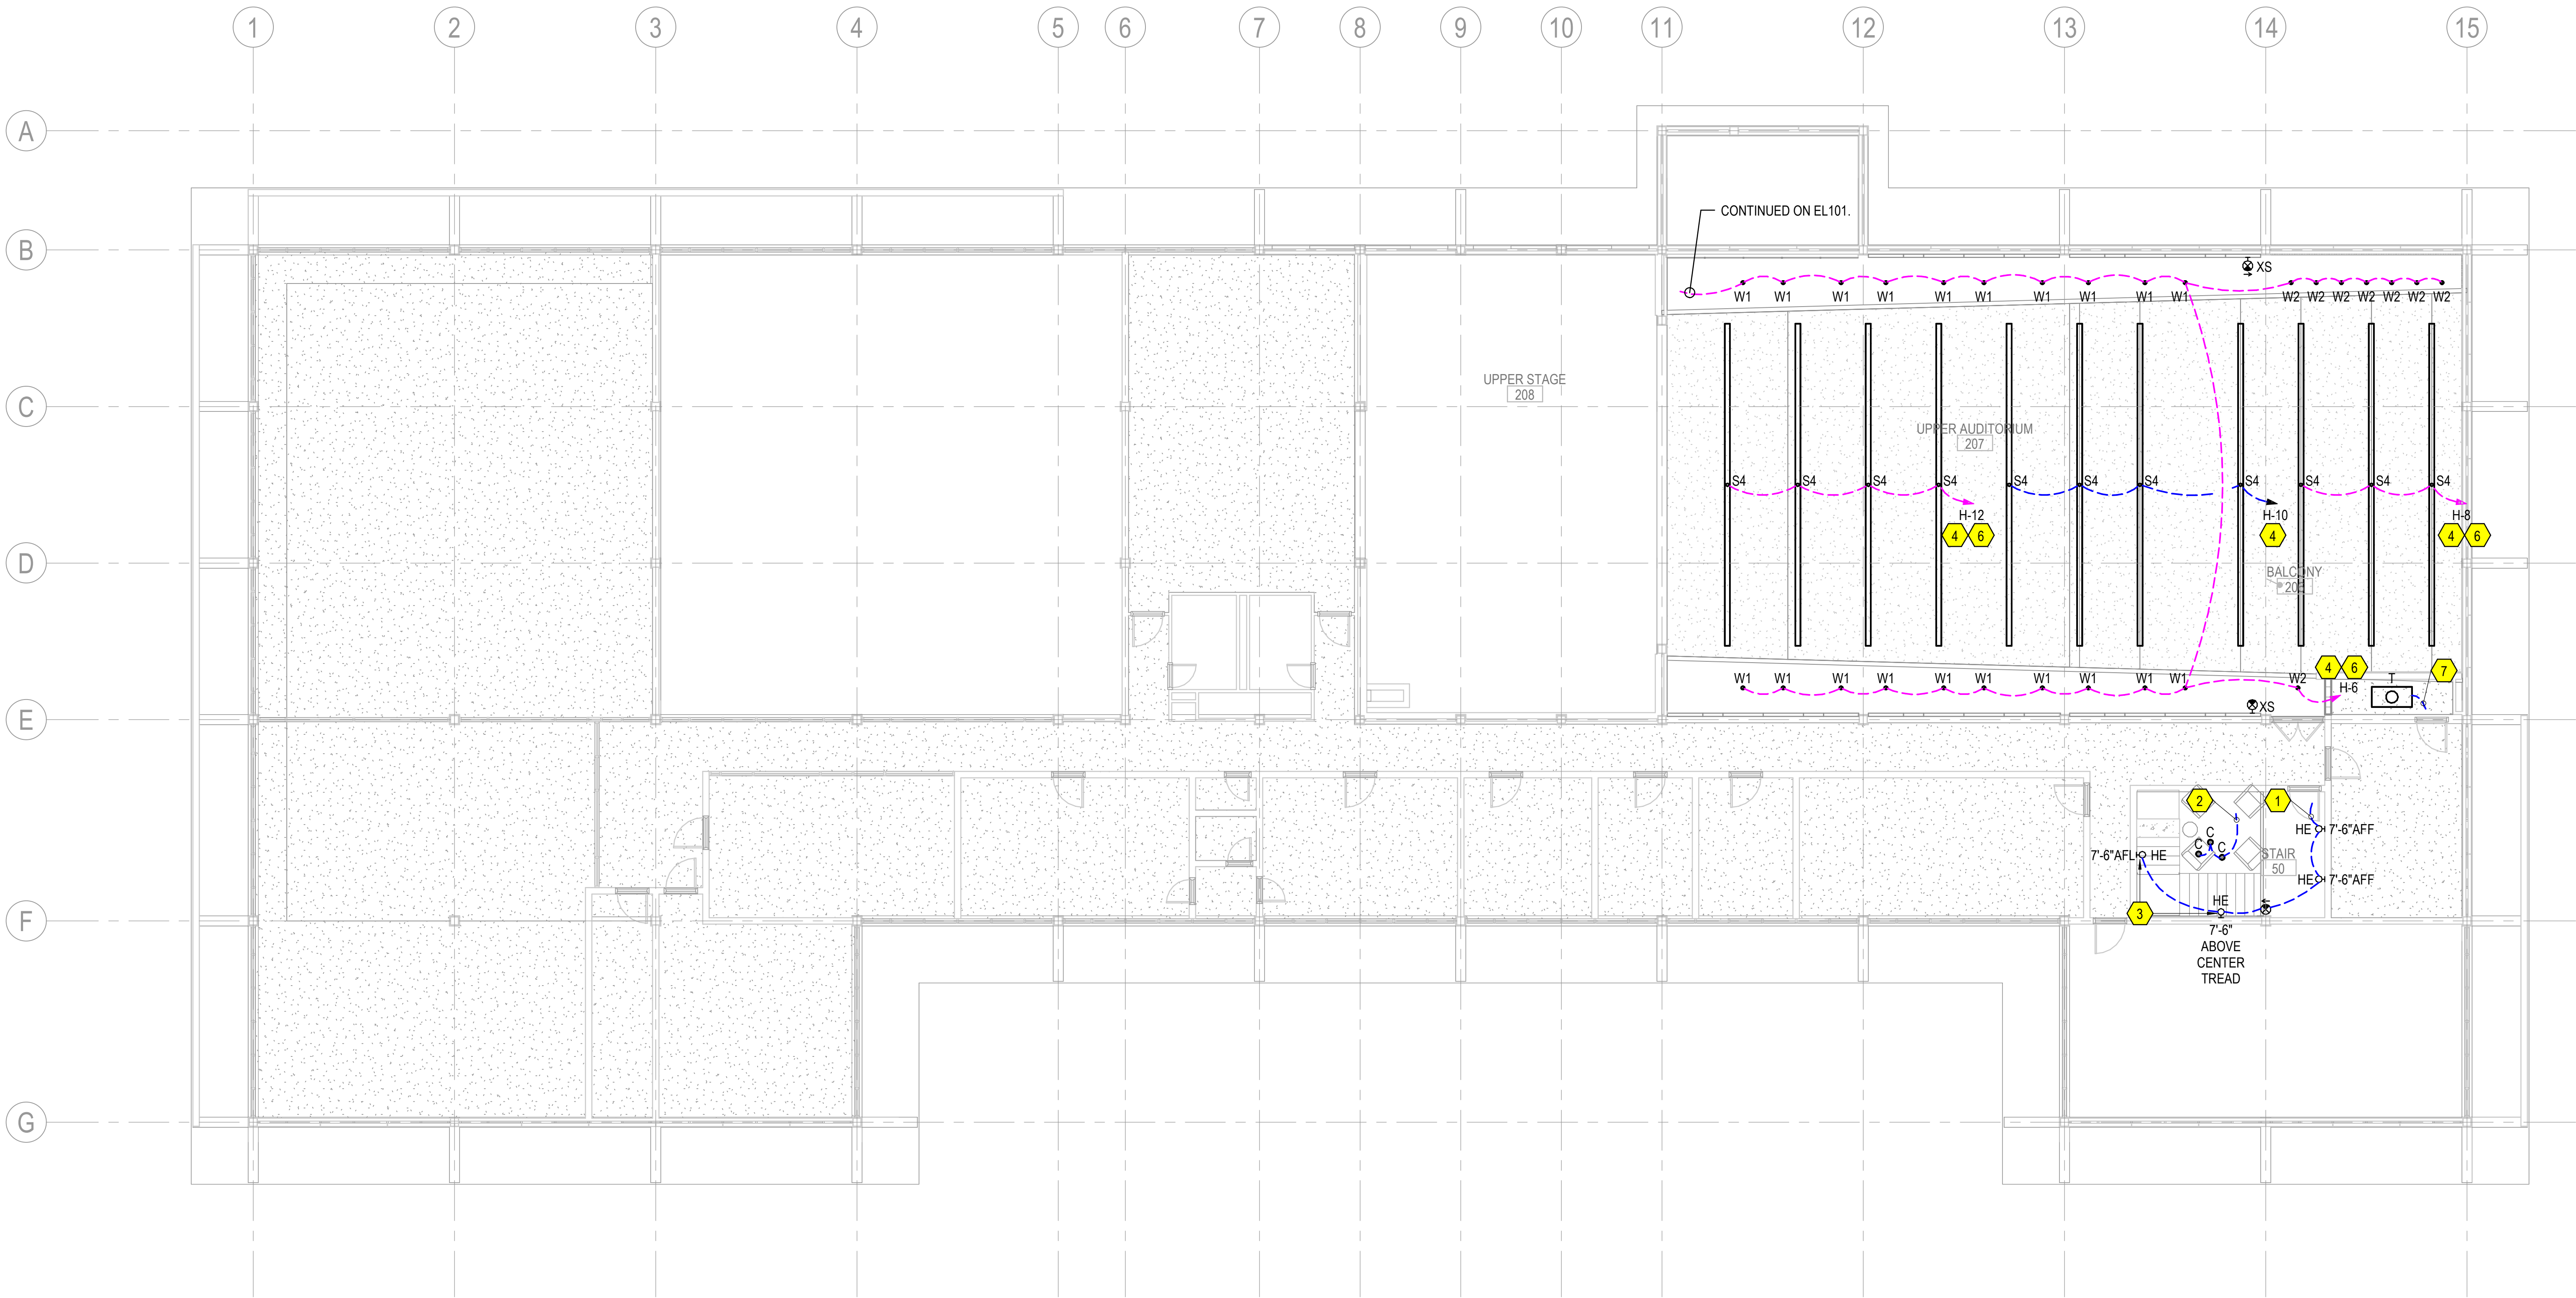


1 SECOND FLOOR LIGHTING PLAN
1/8" = 1'-0"

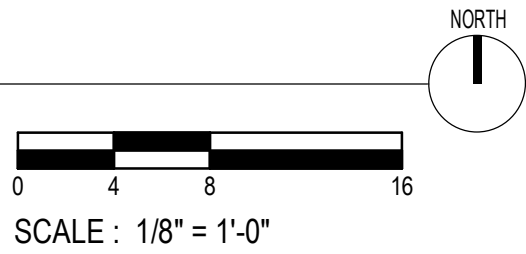

Volume **VOLUME 1**

Design Phase
**CONSTRUCTION
DOCUMENTS**

Revisions		
No.	Date	Description

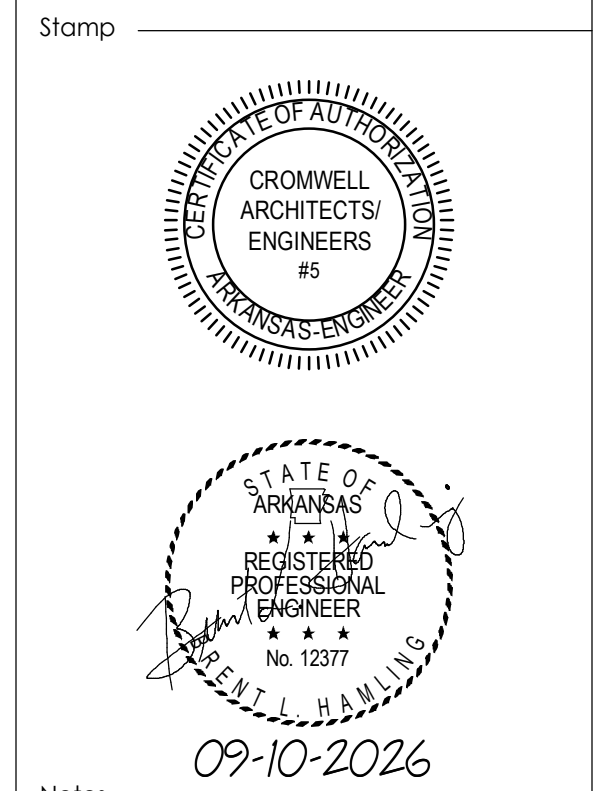

Notes
1. CROMWELL ARCHITECTS ENGINEERS, INC. ALL RIGHTS RESERVED
2. THIS SHEET DESIGNED FOR COLOR PRINTING. CRITICAL INFORMATION MAY BE LOST WITH BLACK AND WHITE PRINTING.

Project Number **2024-060**
Issue Date **09-10-2026**
Sheet Title

**SECOND FLOOR LIGHTING
PLAN**

Sheet Number

EL102