

GENERAL NOTES:

A. SEE NOTES ON EP101.

KEYED NOTES:

- 1 OUTDOOR HVAC UNIT PROVIDES POWER TO THE INDOOR UNIT. COORDINATE CABLE/CONDUCTOR REQUIREMENTS WITH MANUFACTURER.
- 2 CONDUIT STUB-UP FOR AISLE LIGHTING INTEGRAL WITH SEATING. COORDINATE EXACT LOCATION WITH SEATING MANUFACTURER. LIGHT FIXTURE BY SEATING, MANUFACTURER. TRENCH FLOOR AS NECESSARY. COORDINATE LED DRIVER LOCATION(S) WITH SEATING MANUFACTURER. CONNECT TO CIRCUIT H-20 VIA RELAY IN MZC-1. SEE SHULER SHOOK DRAWING SKE 011 AND TL 011.
- 3 EXTEND EXISTING BRANCH CIRCUITS FROM PANEL E TO NEW PANELBOARD. PAINT PANELBOARD ENCLOSURE AND CONDUITS (WHERE EXPOSED ON WALL) TO MATCH EXISTING WALL FINISH. CONCEAL CONDUITS ABOVE CEILING, PATCH CEILING, AND FINISH TO MATCH EXISTING CONDITIONS.
- 4 EXISTING PANEL E ENCLOSURE MAY BE USED AS A JUNCTION BOX FOR BRANCH CIRCUITS. PROVIDE COVER.
- 5 REPLACE EXISTING RECEPTACLE AND WALL PLATE. CONNECT TO EXISTING CIRCUIT.
- 6 THEATRICAL EQUIPMENT FURNISHED BY DIVISION 11.
- 7 CIRCUIT PER SINGLE-LINE DIAGRAM. SEE E-603.
- 8 EACH DUPLEX RECEPTACLE SHALL BE FED FROM A DEDICATED CIRCUIT.
- 9 REFER TO LIGHTING PLANS FOR CIRCUITS ROUTED THROUGH RELAY PANEL.
- 10 SEE DETAIL 9/E-501.

PHILANDER
SMITH
UNIVERSITY

M.L. HARRIS
AUDITORIUM
RENOVATION

Volume
VOLUME 1

Design Phase
CONSTRUCTION
DOCUMENTS

Revisions		
No.	Date	Description

Stamp

CROMWELL ARCHITECTS/ENGINEERS #5

STATE OF ARKANSAS REGISTERED PROFESSIONAL ENGINEER No. 12377

09-10-2026


Notes
1. CROMWELL ARCHITECTS ENGINEERS, INC. ALL RIGHTS RESERVED
2. THIS SHEET DESIGNED FOR COLOR PRINTING. CRITICAL INFORMATION MAY BE LOST WITH BLACK AND WHITE PRINTING.

Project Number
2024-060
Issue Date
09-10-2026
Sheet Title

SECOND FLOOR POWER
PLAN

Sheet Number

EP102

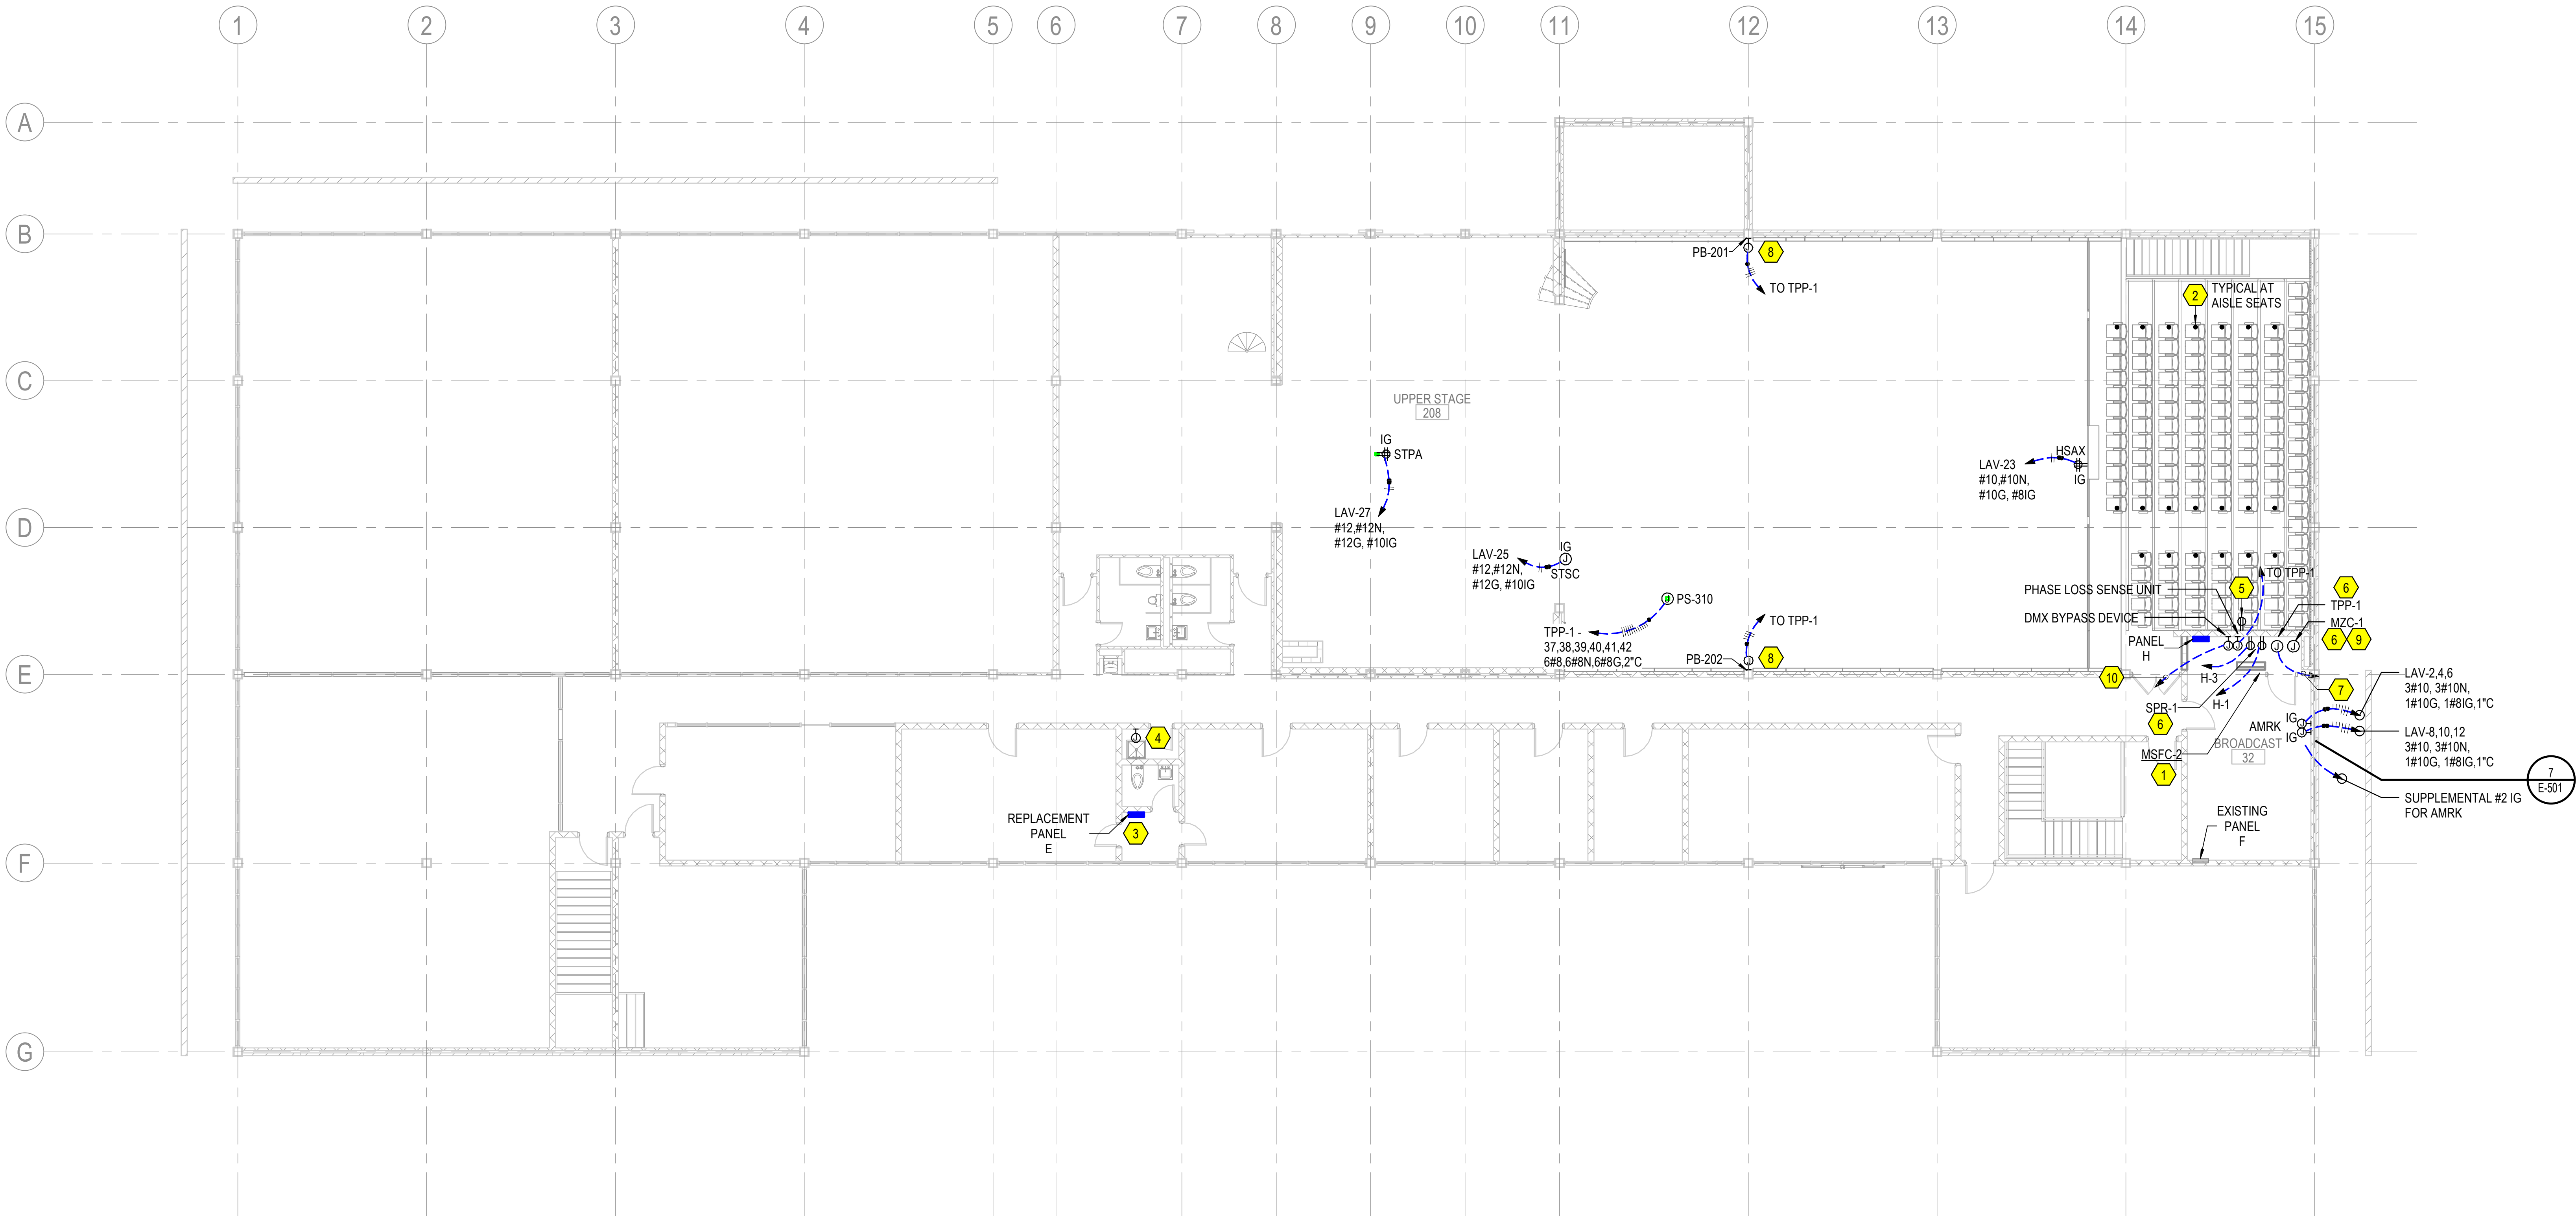

1 SECOND FLOOR POWER PLAN

1/8" = 1'-0"

NORTH

0 4 8 16

SCALE : 1/8" = 1'-0"