

PHILANDER
SMITH
UNIVERSITY




M.L. HARRIS
AUDITORIUM
RENOVATION

GENERAL NOTES:

- A. SEE SHULER SHOOK DRAWINGS FOR ADDITIONAL REQUIREMENTS.
B. COORDINATE DEVICE LOCATIONS, INCLUDING ELEVATIONS, WITH SHULER SHOOK DRAWINGS.

KEYED NOTES:

- 1 DISCONNECT AND REMOVE EXISTING CIRCUIT SERVING LIGHT FIXTURES ABOVE GRIDIRON. RECONNECT EXISTING LIGHT FIXTURES AS INDICATED.
2 CONTROLLED VIA RELAY IN MZC-1. SEE SHULER SHOOK DRAWING SKE 011 AND TL 011.
3 SEE SHULER SHOOK DRAWING SKE 303 FOR MOUNTING.
4 SMOKE VENT ON ROOF. COORDINATE LOCATION OF MANUAL SWITCH AT STAGE LEVEL AND EXTEND CIRCUIT AS REQUIRED.

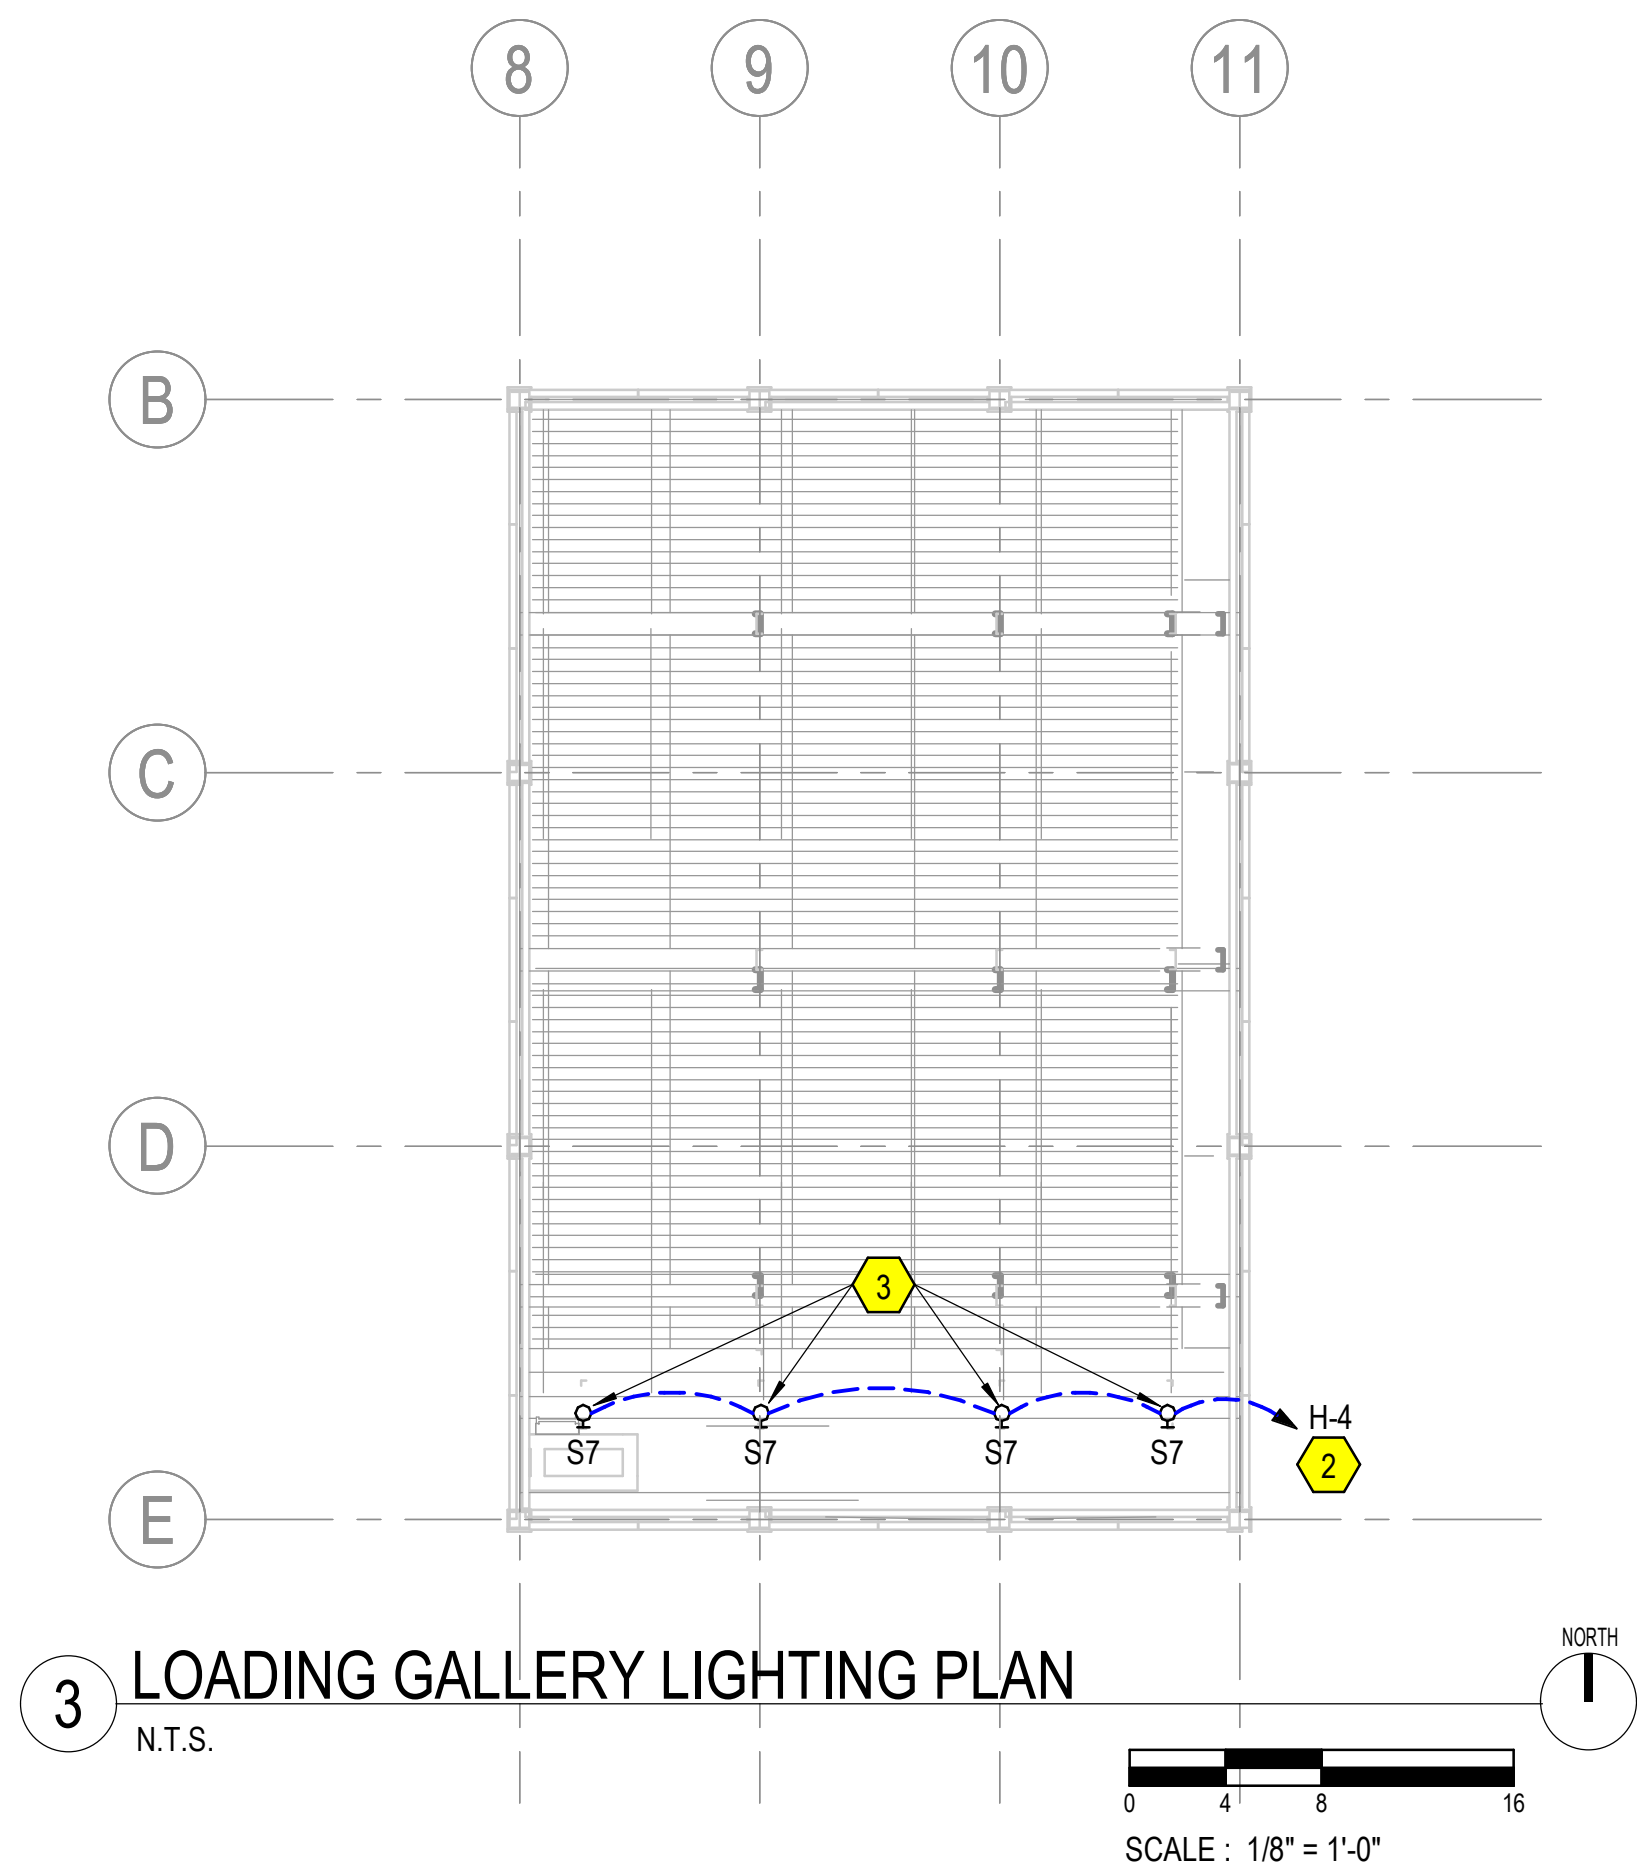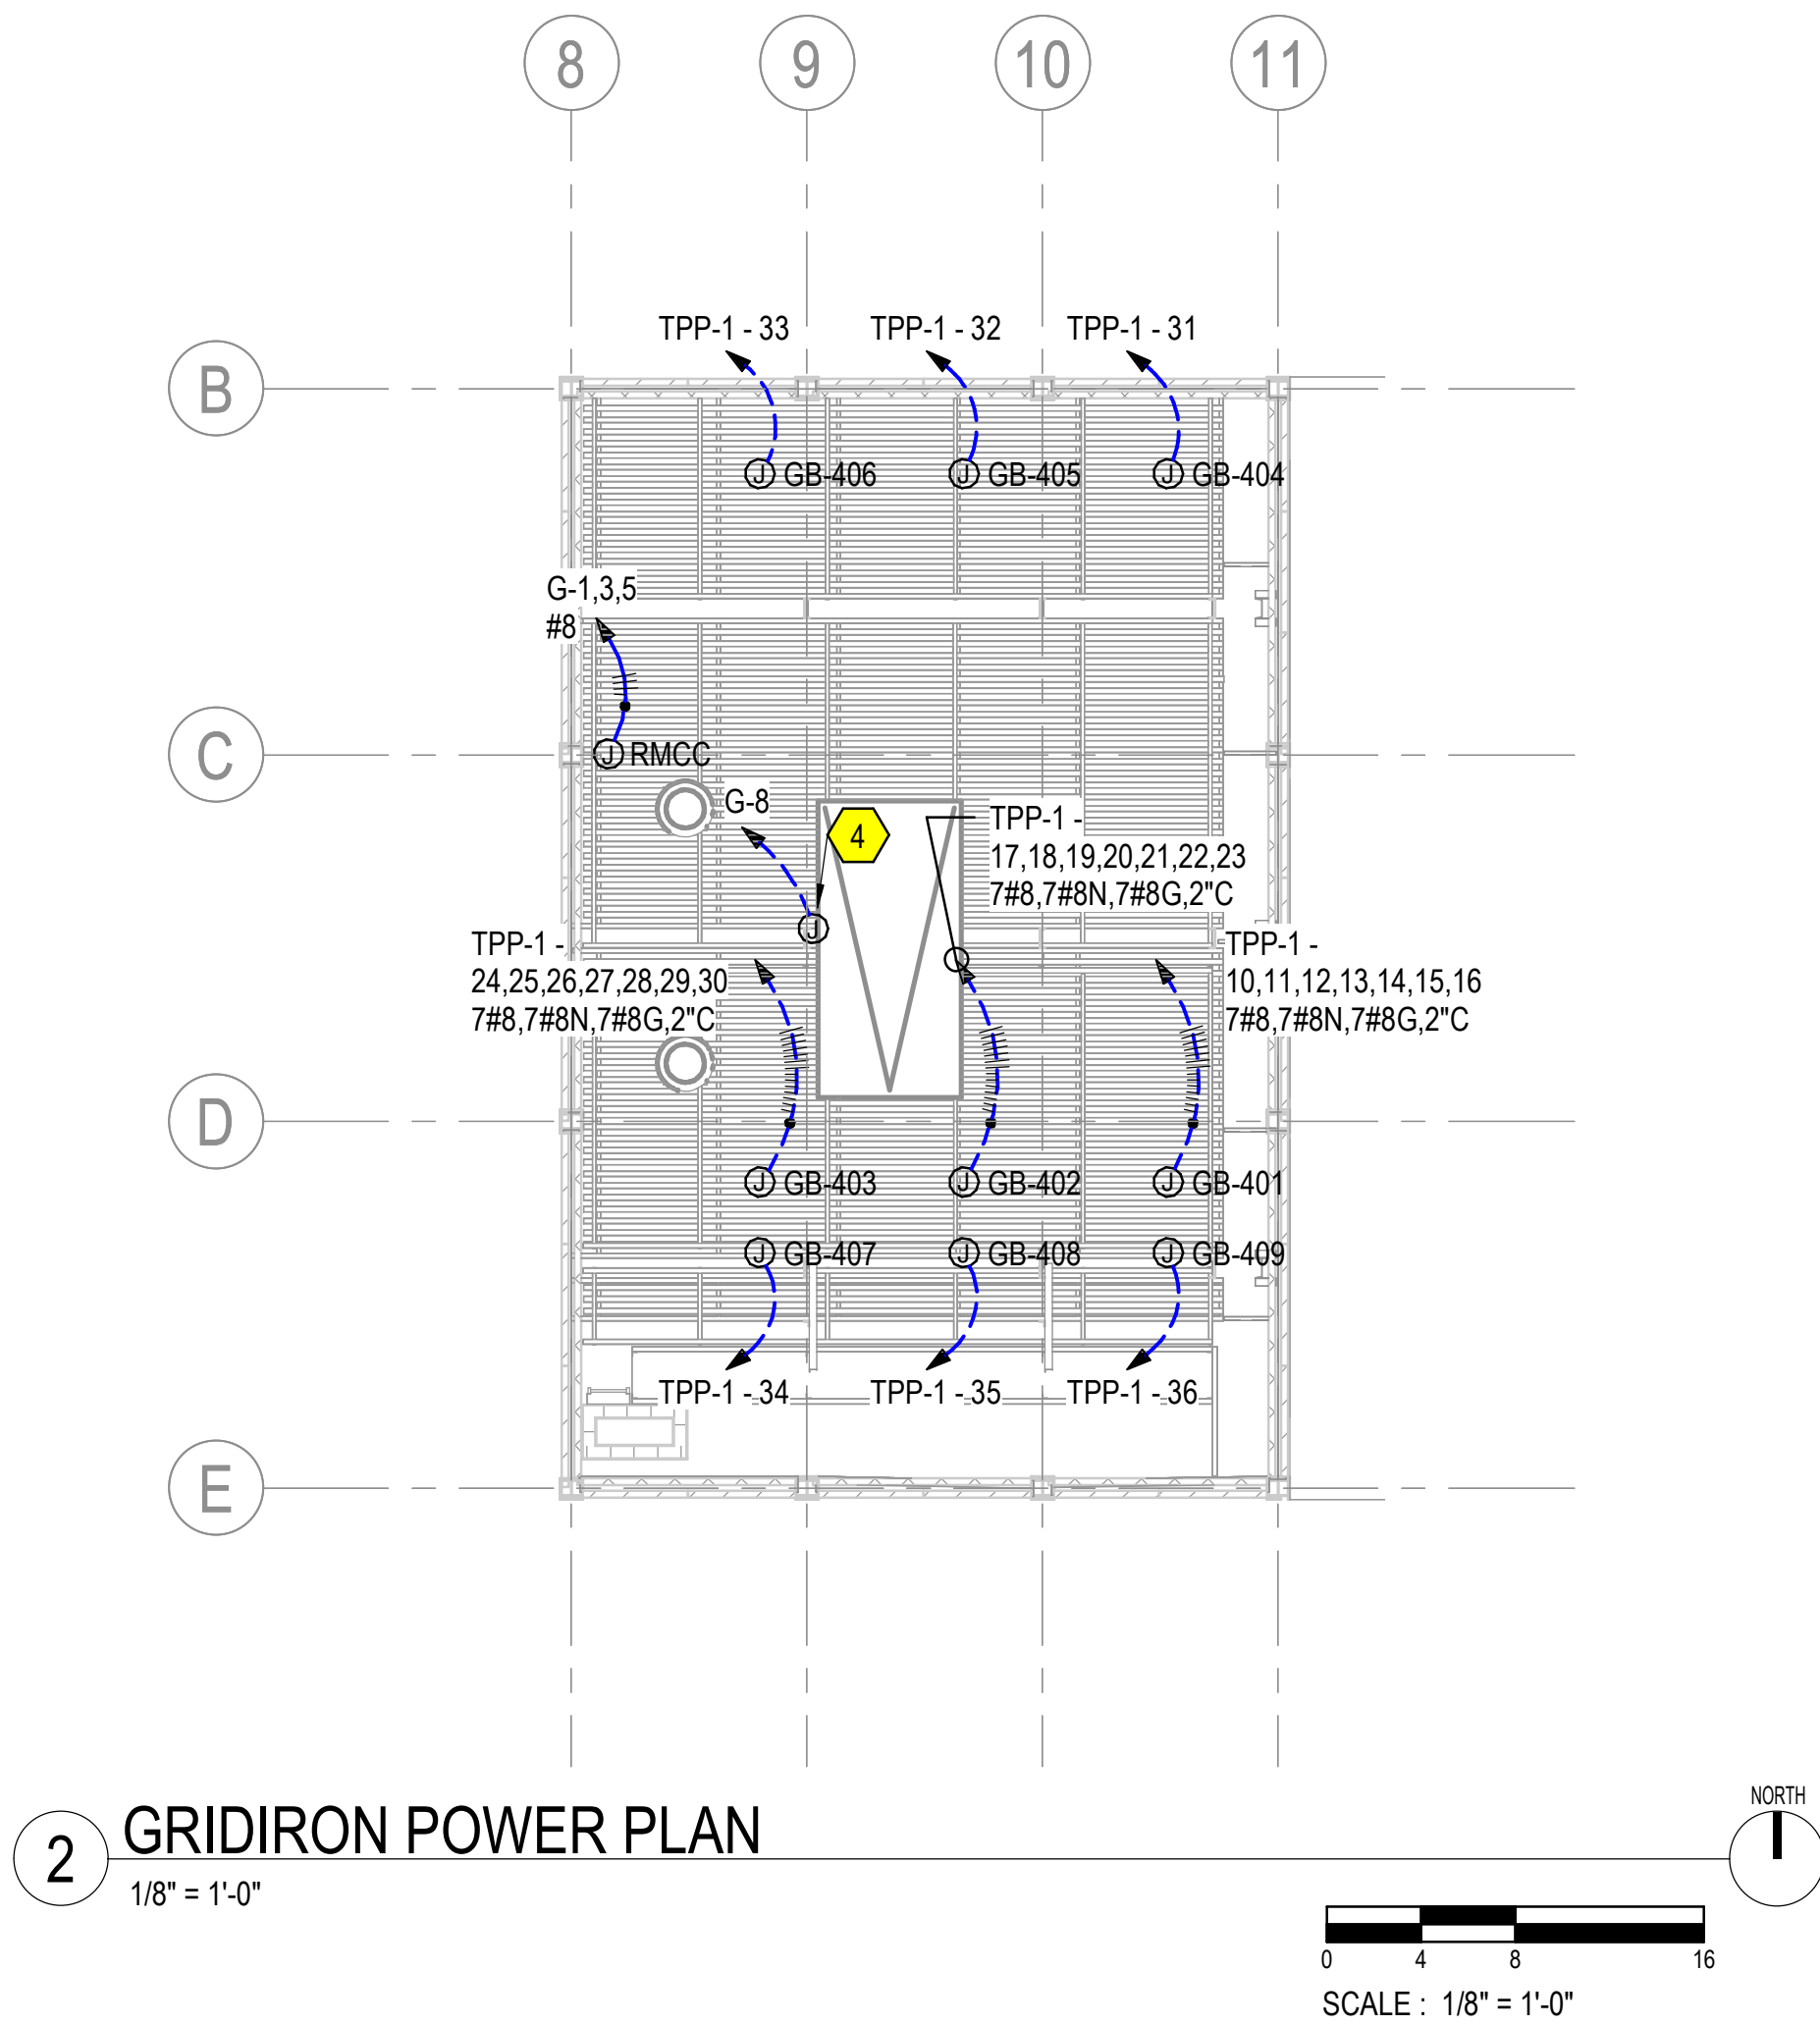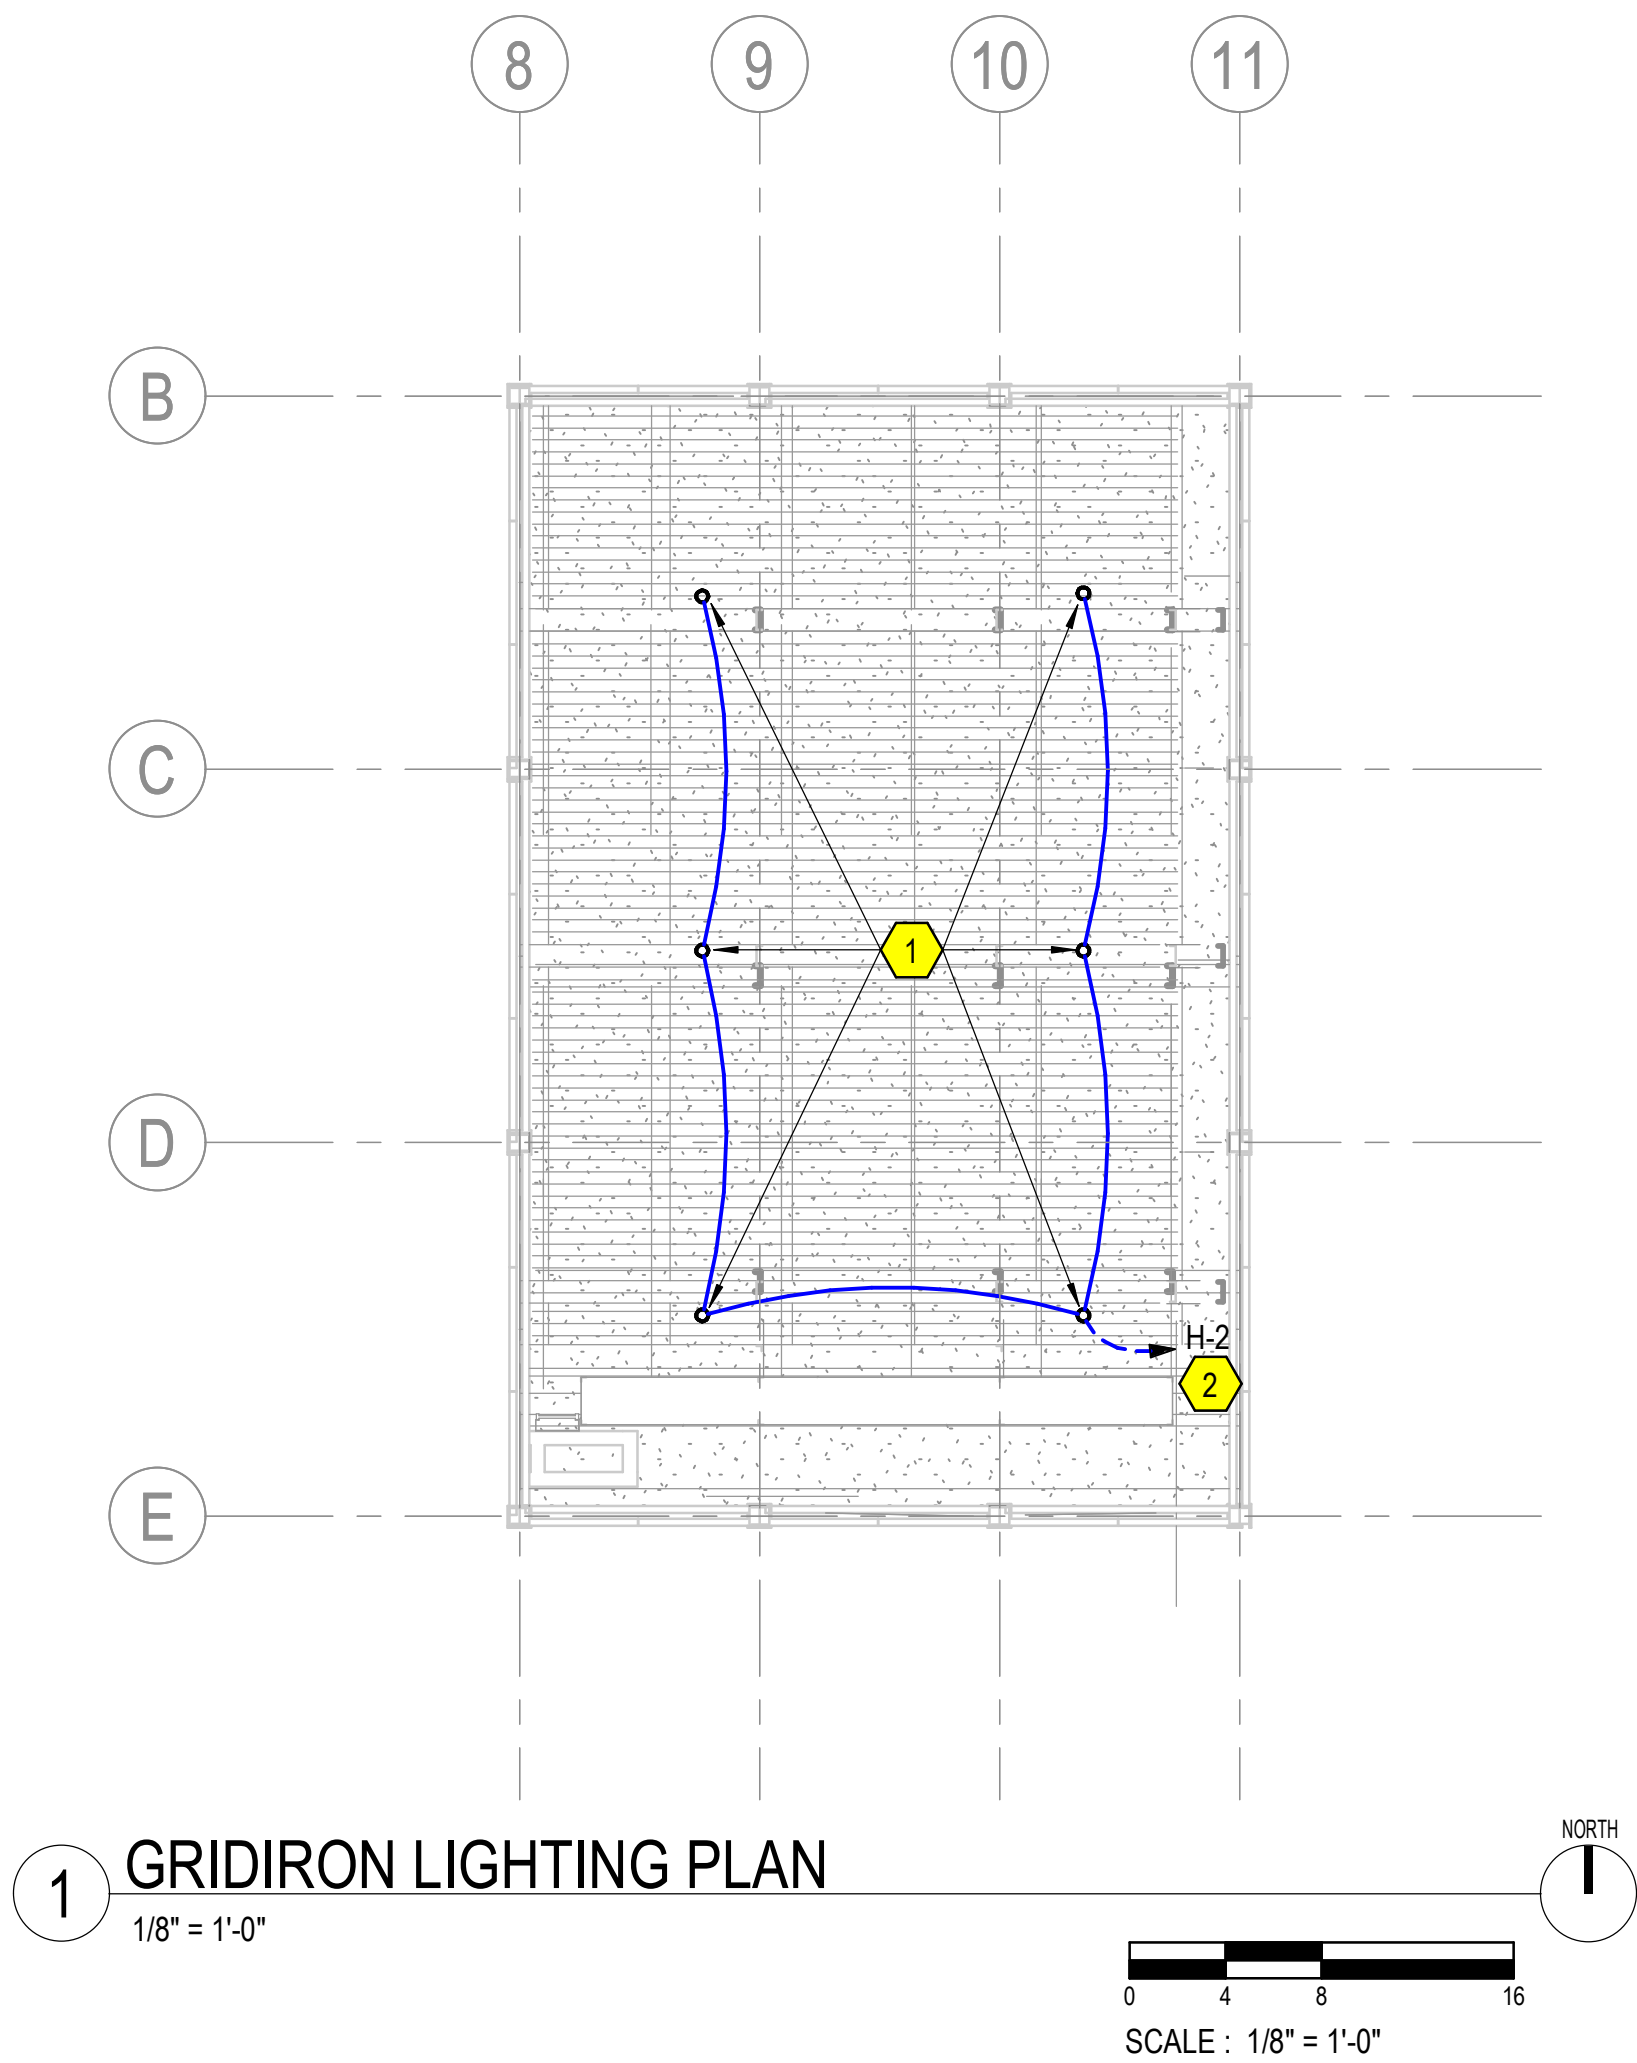

Volume
VOLUME 1

Design Phase
CONSTRUCTION
DOCUMENTS

Revisions		
No.	Date	Description

Stamp
CROMWELL ARCHITECTS/ENGINEERS
#5
STATE OF ARKANSAS
REGISTERED PROFESSIONAL ENGINEER
No. 12377
09-10-2026

Notes
1. CROMWELL ARCHITECTS ENGINEERS, INC. ALL RIGHTS RESERVED
2. THIS SHEET DESIGNED FOR COLOR PRINTING. CRITICAL INFORMATION MAY BE LOST WITH BLACK AND WHITE PRINTING.
Project Number
2024-060
Issue Date
09-10-2026
Sheet Title

UPPER LEVEL STAGE
ELECTRICAL PLANS

Sheet Number
E-103