

ANY DIVISION 26 SCOPE OF
WORK SHOWN IS FOR
REFERENCE ONLY

REFER TO NOTE 3 AND THE
WORK SCOPE
SPECIFICATION TABLE ON
AV001



Schuler Shook

LIGHTING DESIGN / THEATRE PLANNING / AUDIO VIDEO DESIGN

Dallas

T +1 214 747 8300

schulershook.com



CROMWELL

1300 East 6th Street Little Rock, AR 72202

501.372.2900 cromwell.com

Project



PHILANDER
SMITH UNIVERSITY

PHILANDER
SMITH
UNIVERSITY

M.L. HARRIS
AUDITORIUM
RENOVATION

Volume **VOLUME 2**

Design Phase

**CONSTRUCTION
DOCUMENTS**

Revisions		
No.	Date	Description

Stamp

- Notes
- CROMWELL ARCHITECTS ENGINEERS, INC.
ALL RIGHTS RESERVED
 - THIS SHEET DESIGNED FOR COLOR PRINTING.
CRITICAL INFORMATION MAY BE LOST WITH
BLACK AND WHITE PRINTING.

Project Number **2024-060**


Issue Date **09-10-2026**

Sheet Title

AV DEMO FLOOR PLAN -
STAGE

Sheet Number

AVD101

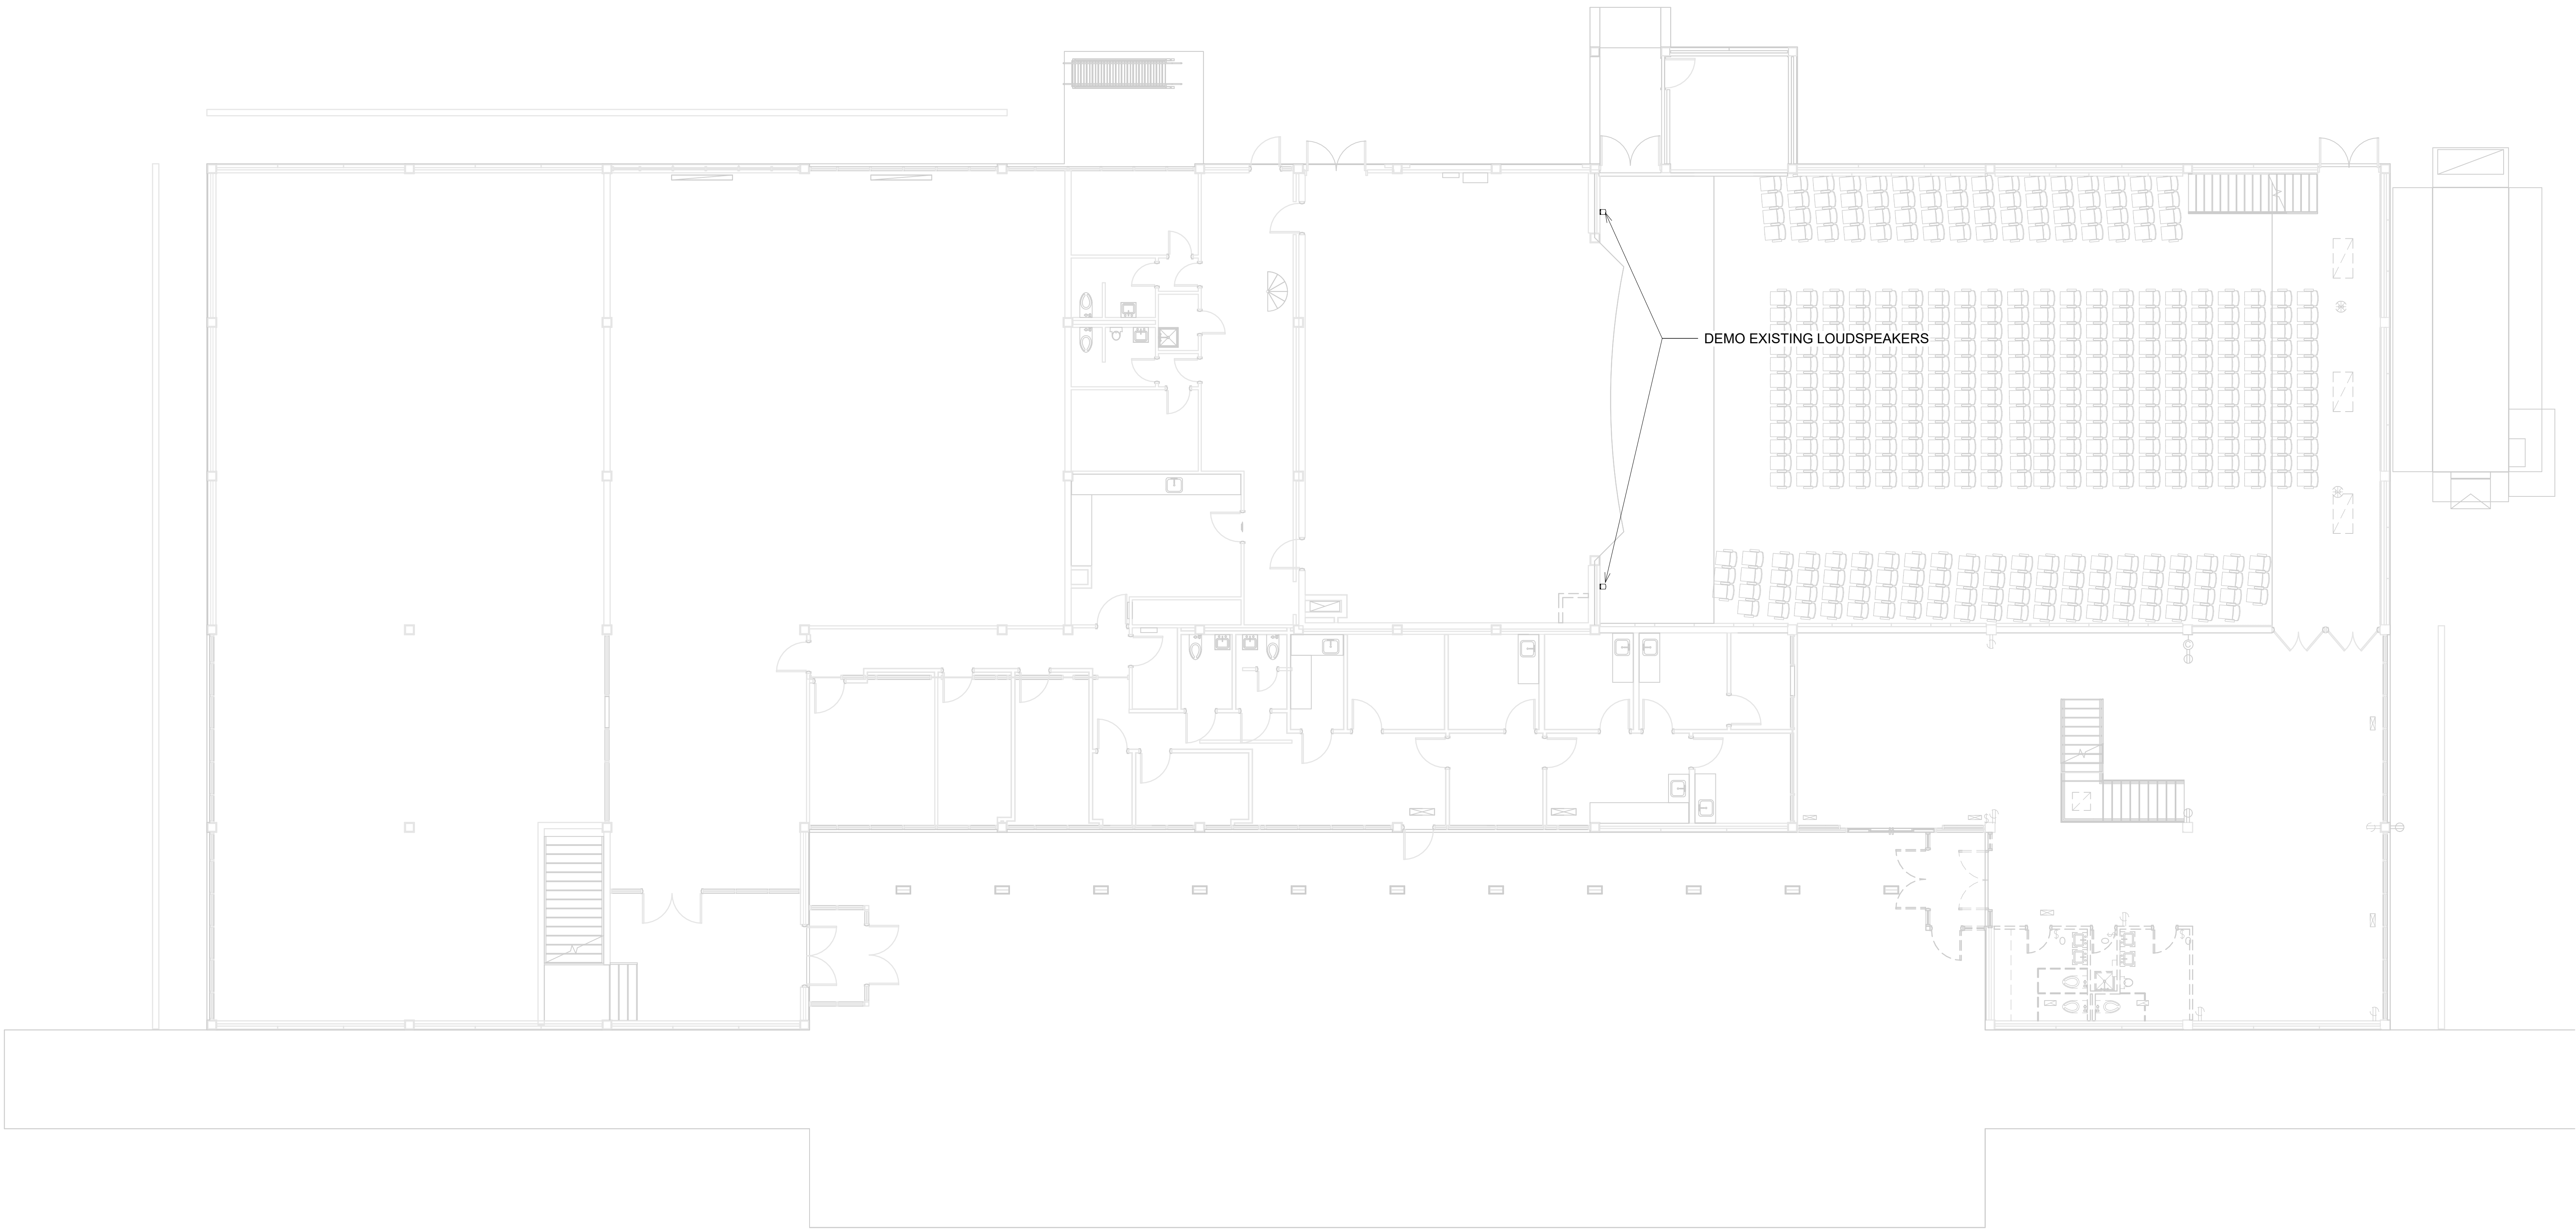

1 AUDITORIUM FLOOR DEMO PLAN
1/8" = 1'-0"