



PSW Job Number:
699H

SERVICE
CENTER
WAREHOUSE
ADDITION
LITTLE ROCK, ARKANSAS

PERMIT AND BID ISSUE
Issue Date:
9/24/2026

REVISIONS		
NUMBER	DATE	DESCRIPTION

Contents:
FIRST FLOOR
NOTE PLAN

THIS PAGE IS BEST
VIEWED IN COLOR

A101

PLAN SYMBOLS LEGEND

VIEW DIRECTION
DETAIL NUMBER, TYP.
SHEET NUMBER, TYP.

VIEW DIRECTION
DETAIL NUMBER
SHEET NUMBER

1
A101

1
A101

1
A101

1
A101

0

0

BUILDING ELEVATIONS, MAIN

BUILDING SECTION KEY

WALL SECTION KEY

DETAIL CALLOUT

INTERIOR ELEVATION

COLUMN GRID, NEW

COLUMN GRID, EXISTING

DOOR TAG, STANDARD

WINDOW TAG
REFER TO WINDOW SCHEDULE(S):
SHEET A740, A741, etc.

ALUMINUM WINDOW SYSTEM TAG
REFER TO WINDOW SCHEDULE(S):
SHEET A740, A741, etc.

Room name
101


WALL PARTITION TAG
REFER TO PARTITION SCHEDULE:
SHEET A701, A702, etc.

FIRE EXTINGUISHER CABINET
REFER TO LIFE SAFETY PLAN FOR TYPES


FIRE EXTINGUISHER - BRACKET MOUNT
REFER TO LIFE SAFETY PLAN FOR TYPES

NO. OF REVISION
ON SHEET

REVISION CLOUD W/ DELTA

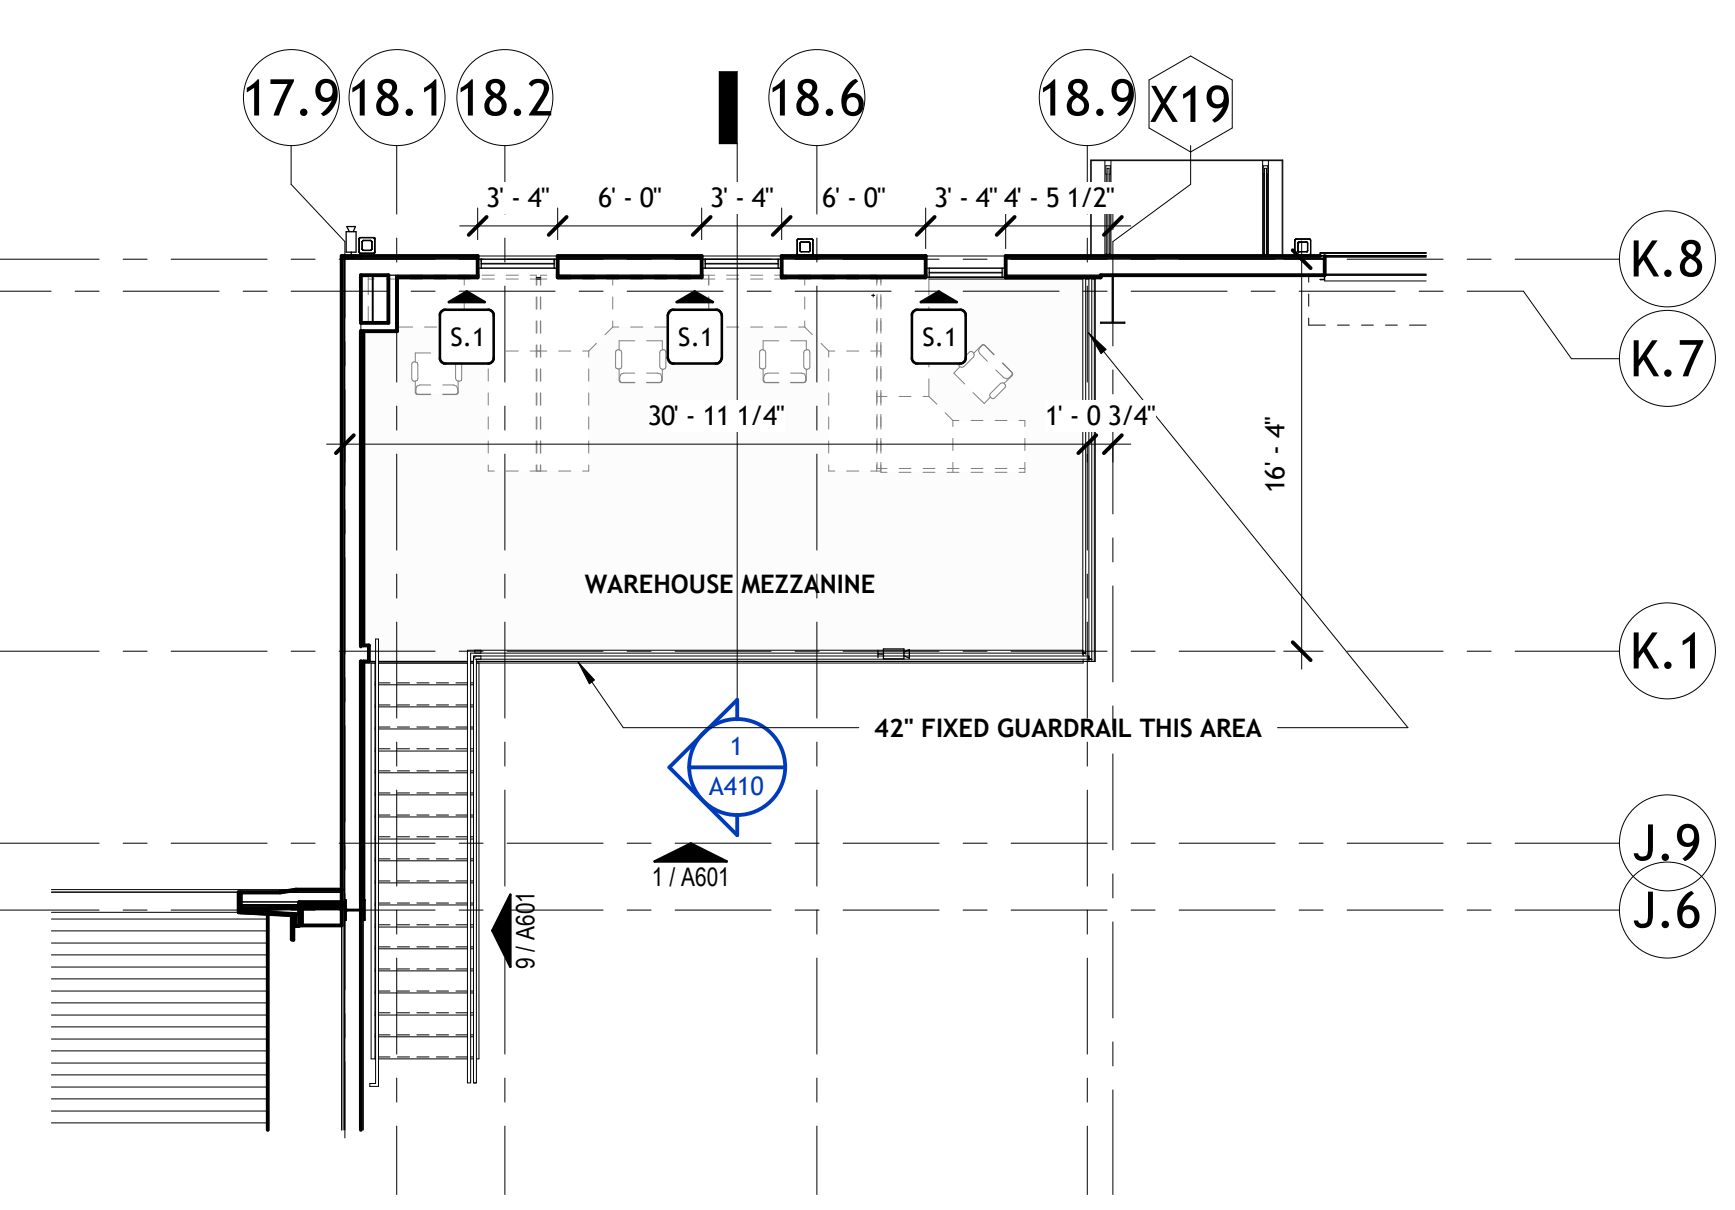

2 WAREHOUSE MEZZANINE FLOOR PLAN
1/8" = 1'-0"

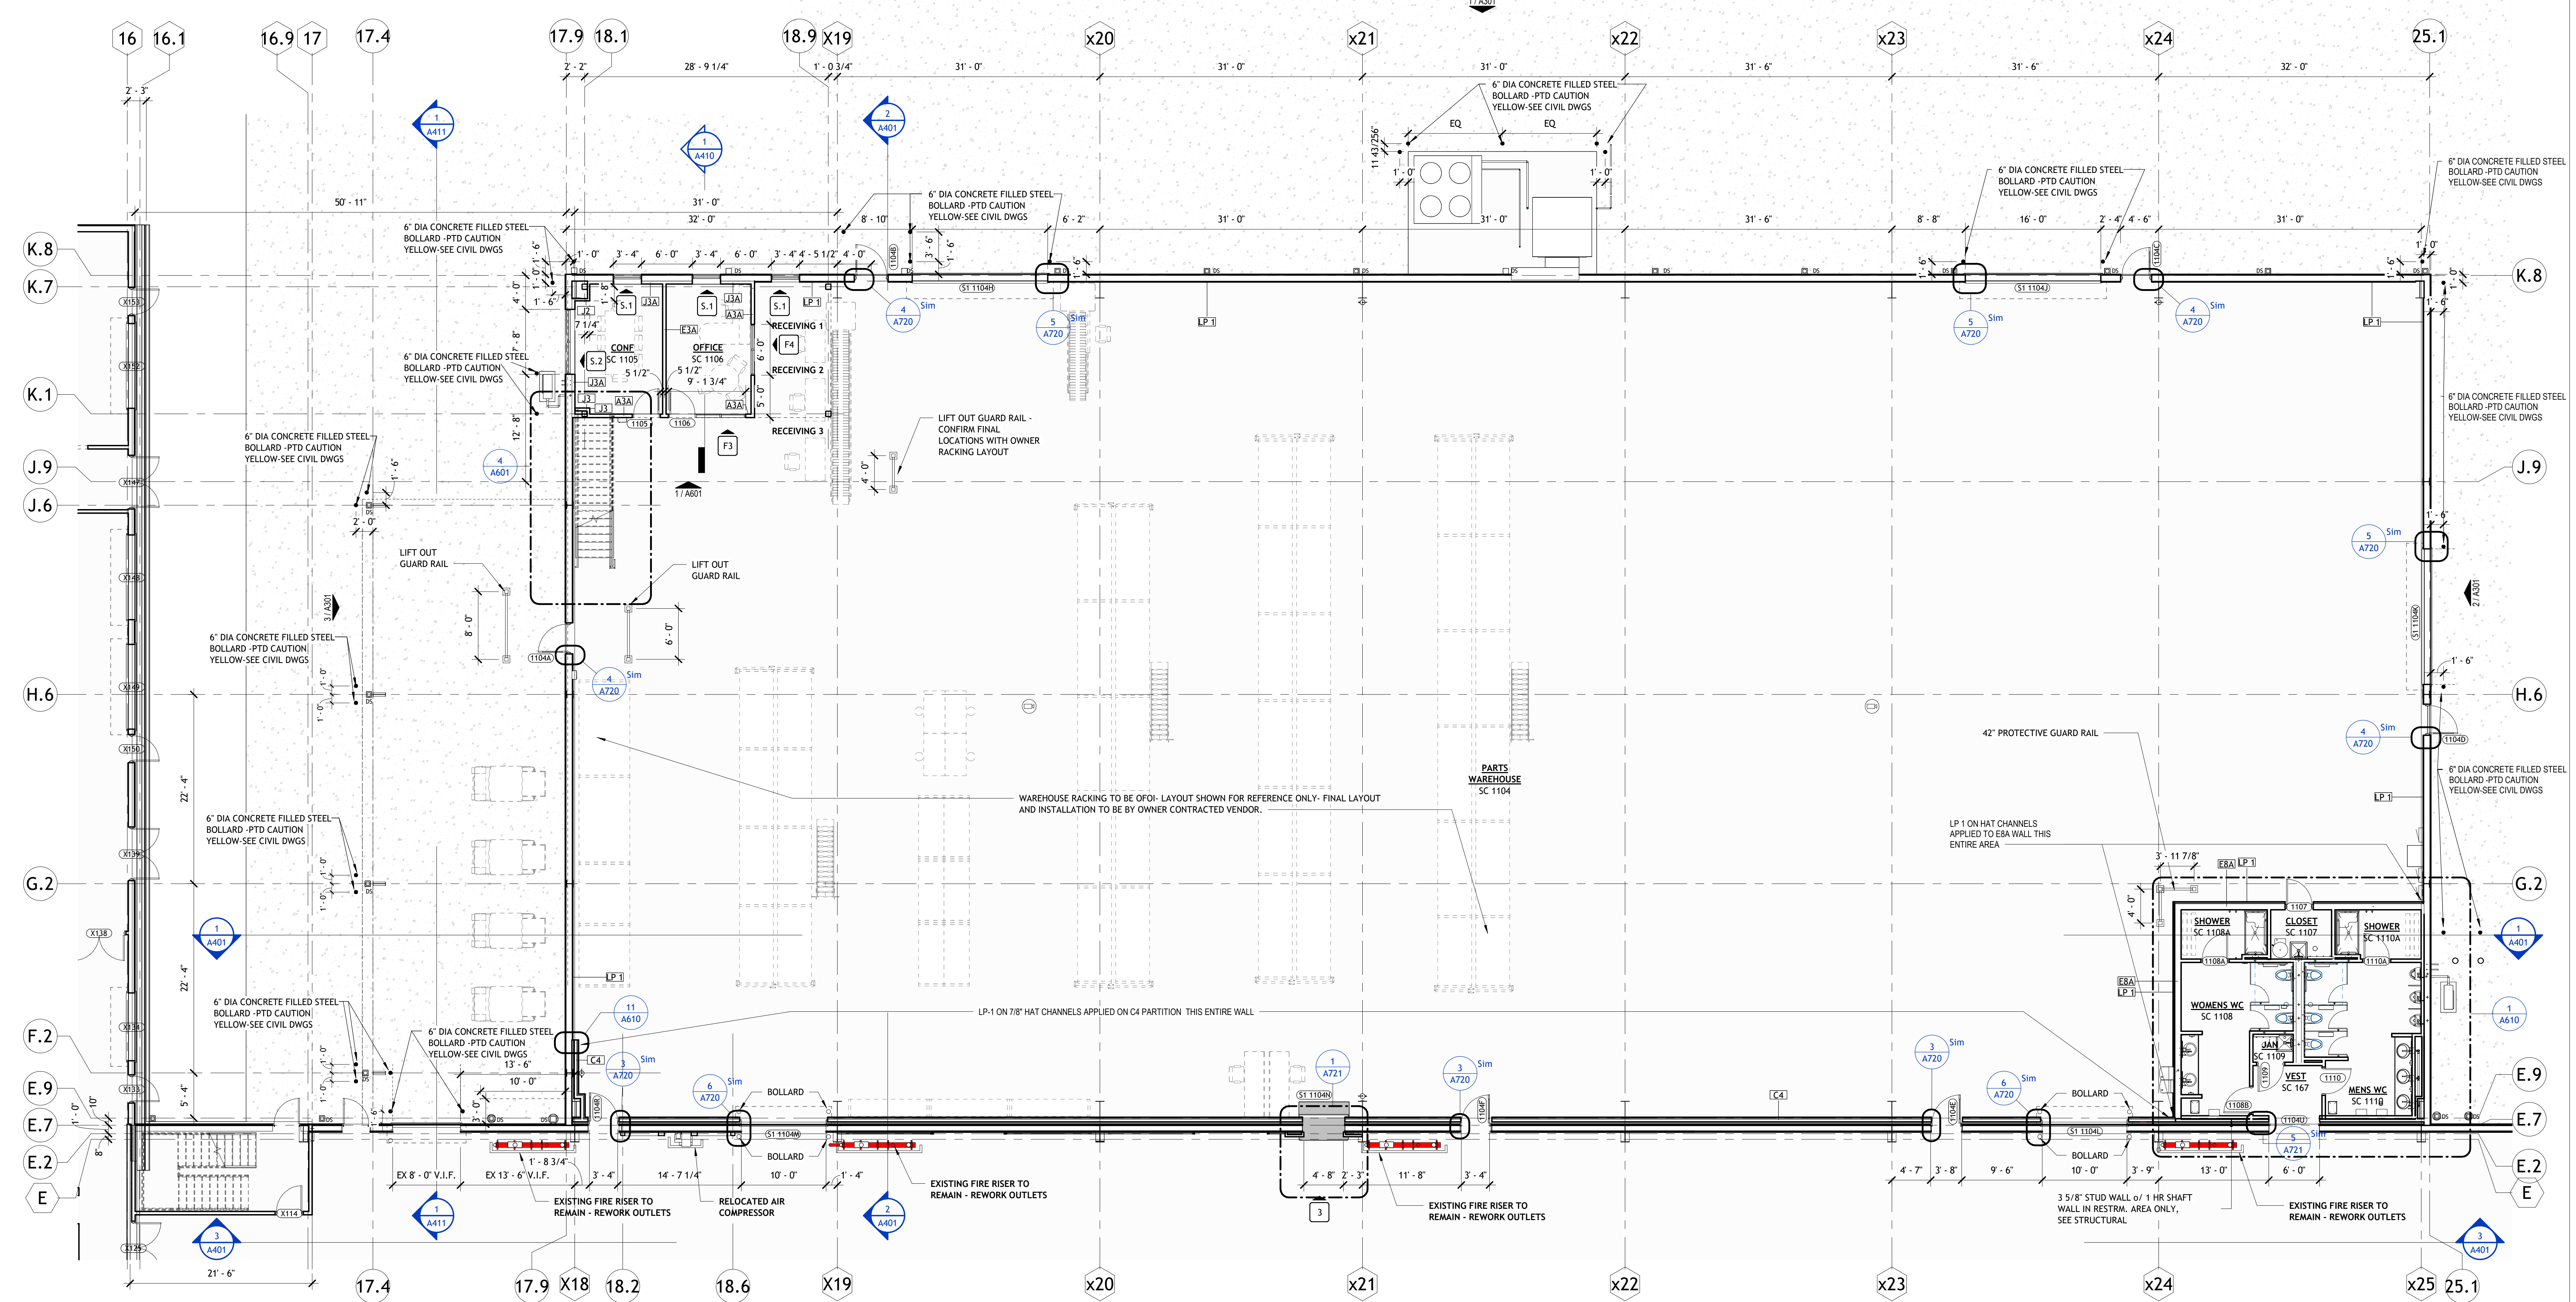

NO SILICONE SEALANT ALLOWED ON PROJECT TO ALIGN WITH REQUIREMENTS OF INTERNATIONAL
FIRE CODE SECTION, 2404.3.2.1

1 WAREHOUSE ADDITION FLOOR PLAN
1/8" = 1'-0"

Architect: POLK STANLEY WILCOX, INC. (P) 00000001, (E) 00000001, (S) 00000001, (C) 00000001
Structural: OLSSON ENGINEERING, INC. (P) 00000001, (E) 00000001, (S) 00000001, (C) 00000001
MEPFP: INSIGHT ENGINEERING, INC. (P) 00000001, (E) 00000001, (S) 00000001, (C) 00000001
10/4/2026 1:28:29 PM