

2° CW 11/2° CW 12' HW


11/2° CW 11/2° C

DRAIN, WASTE, AND VENT RISER

NOT TO SCALE

2 DOMESTIC WATER RISER
NOT TO SCALE



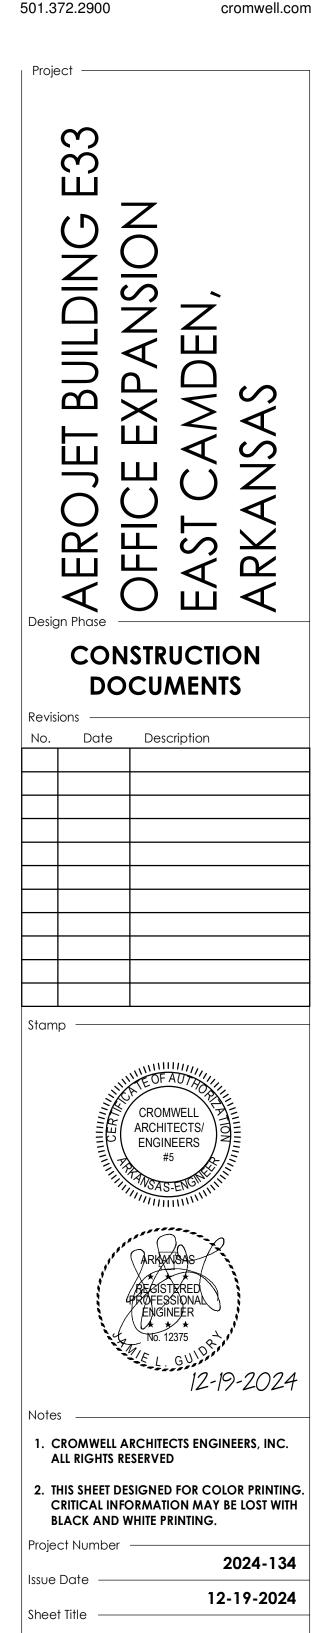

PLUMBING RISERS

Sheet Number