



1 DUCT TAKEOFF NOT TO SCALE

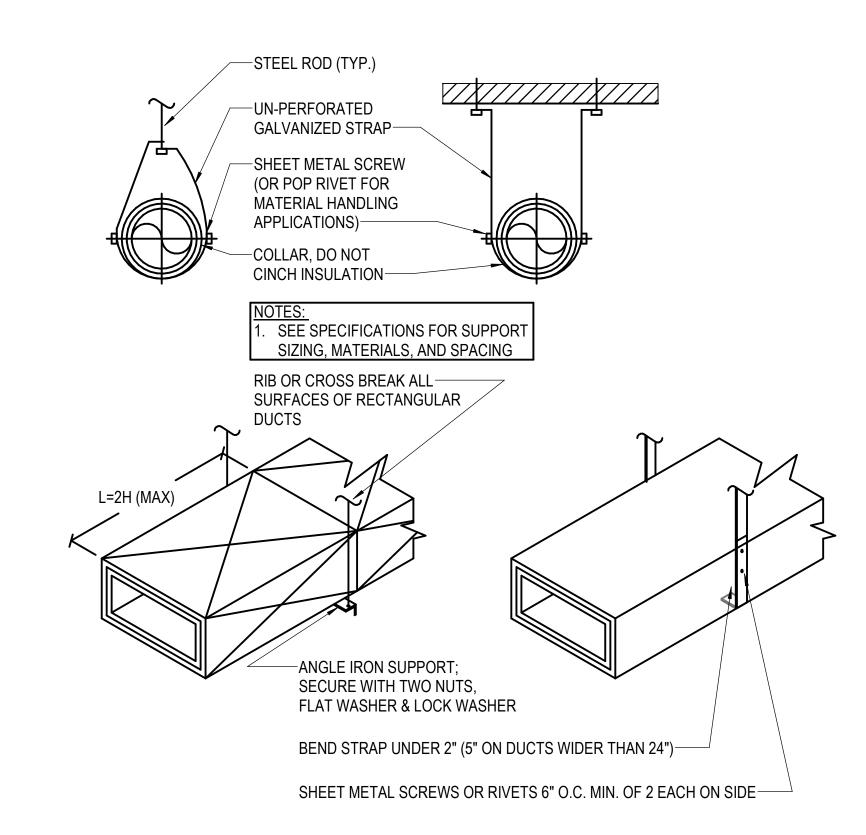


DUCT ACCESSORY - DUCT HANGERS NOT TO SCALE

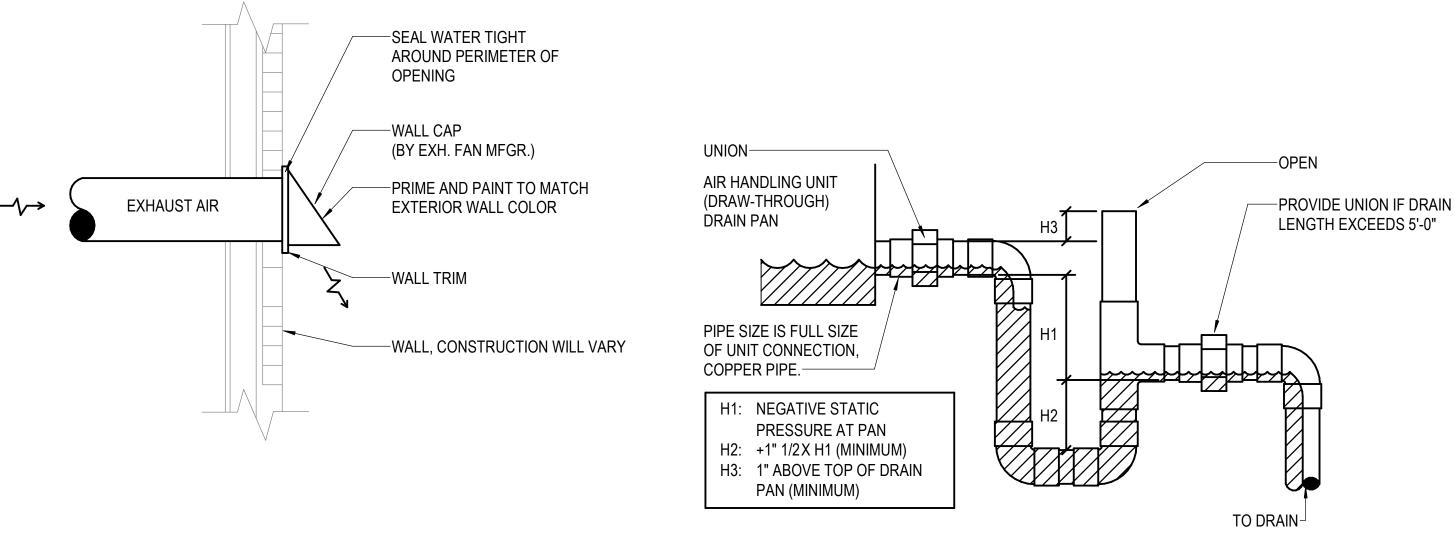


DRAW-THROUGH CONFIGURATION (AHU-1,2,3 & PAHU-1)

8 CONDENSATE PIPING - DRAIN TRAP
NOT TO SCALE

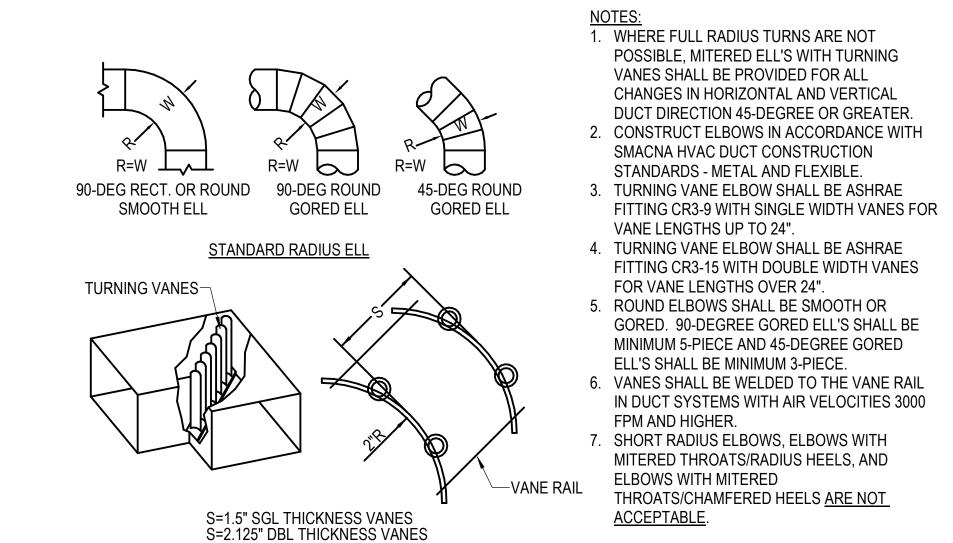


DUCT FITTING - DUCT ELBOW SPEC 2 DUCT FI


MITERED ELL

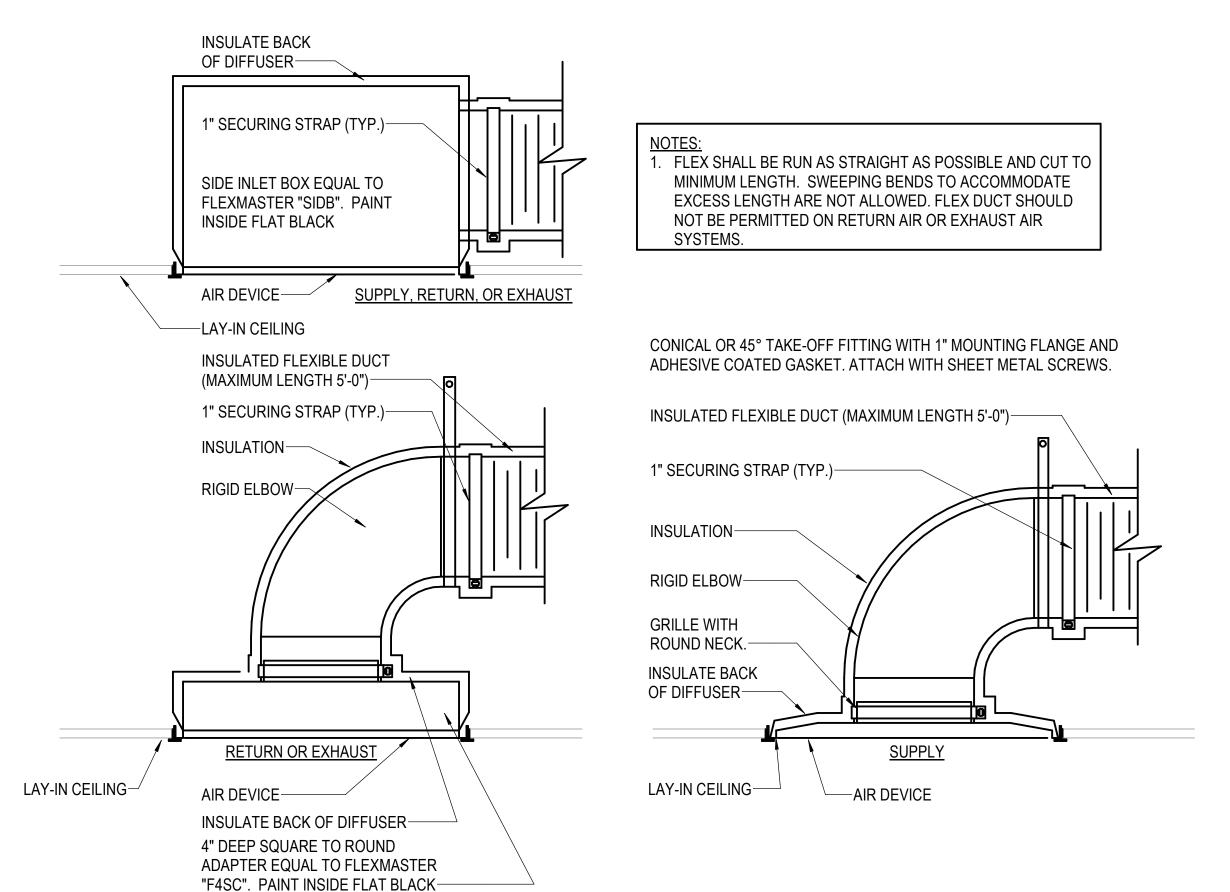


AIR TERMINAL - AIR DEVICE CONNECTION NOT TO SCALE

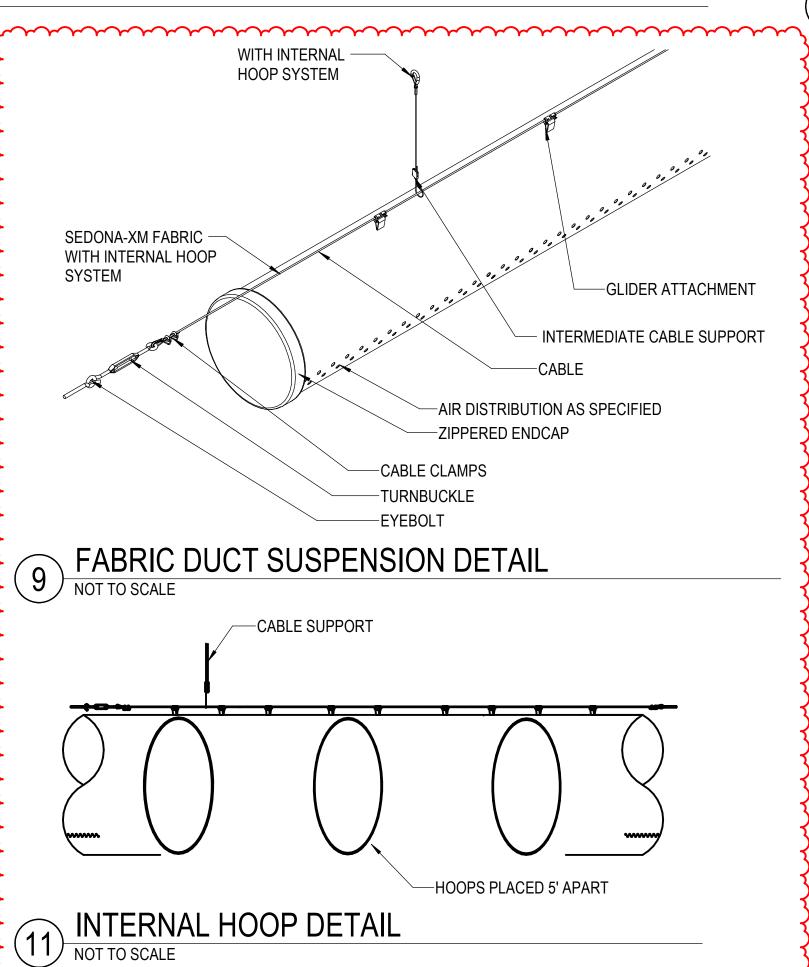


//www.www.www.m//

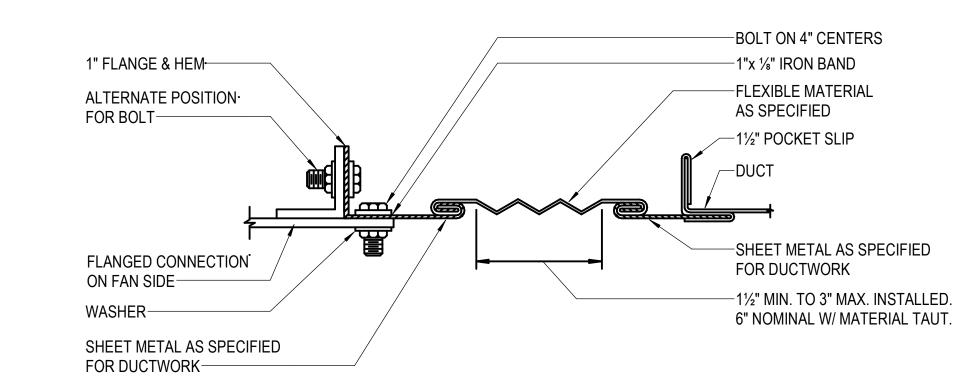

3 DUCT - FLEXIBLE CONNECTION RECTANGUALR NOT TO SCALE

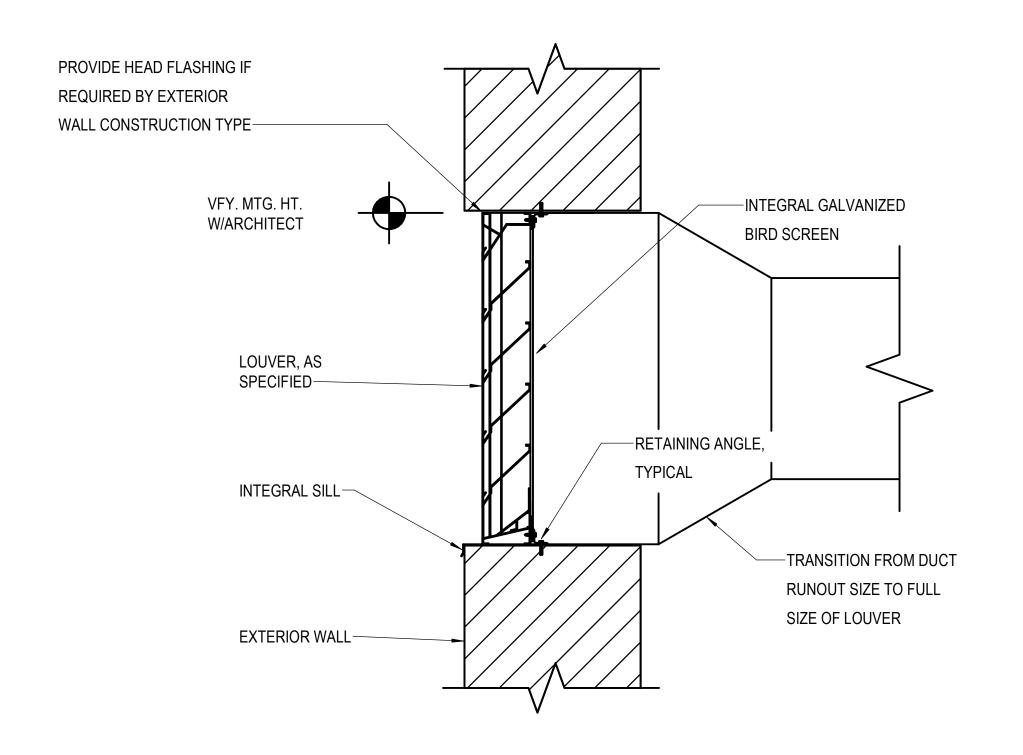




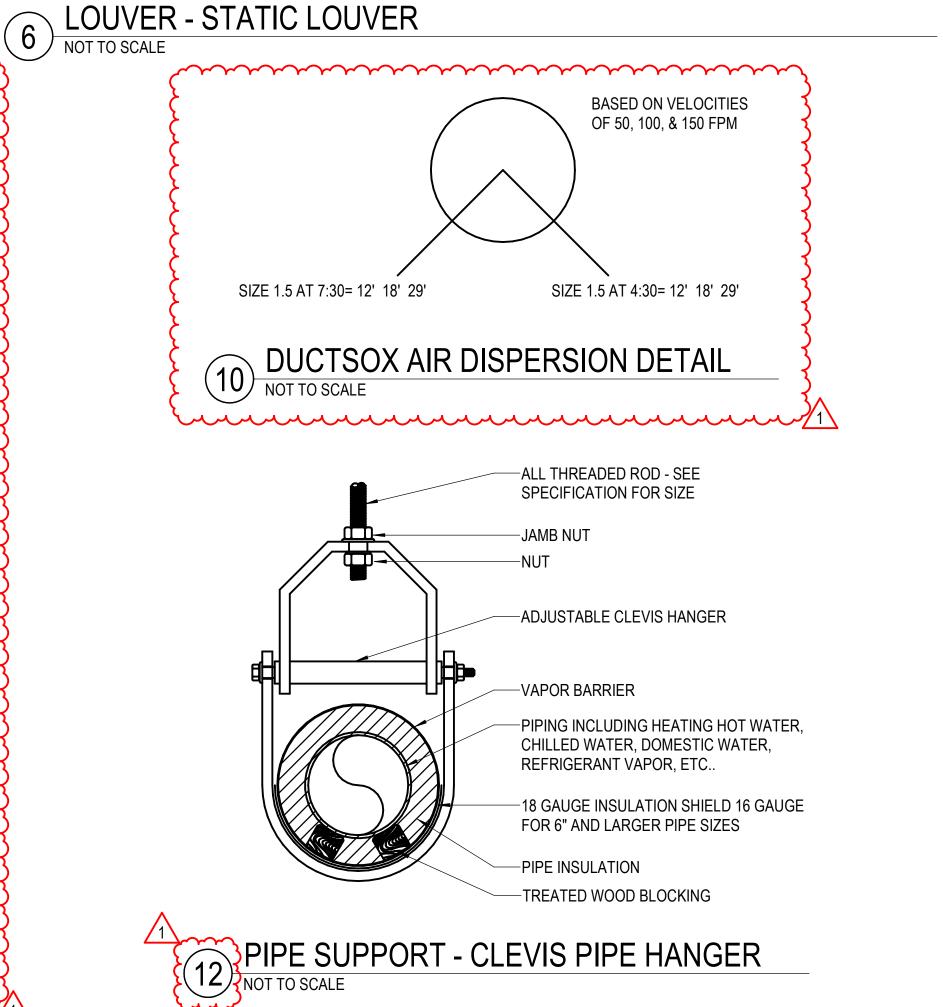





Design Phase CONSTRUCTION **DOCUMENTS** Date Description 1 | 11-15-2024 | ADD 003

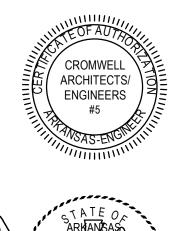



1. CROMWELL ARCHITECTS ENGINEERS, INC. ALL RIGHTS RESERVED 2. THIS SHEET DESIGNED FOR COLOR PRINTING. CRITICAL INFORMATION MAY BE LOST WITH BLACK AND WHITE PRINTING.

Project Number 2023-249-20 Issue Date -09-23-2024 Sheet Title -

MECHANICAL DETAILS

Sheet Number -