



UPS REPLACEMENT
STATE DATA CENTER WEST
DEPARTMENT OF SHARED ADMINISTRATIVE SERVICES
OFFICE OF STATE TECHNOLOGY
LITTLE ROCK, ARKANSAS
DBA PROJECT # 470-25-01

LITTLE ROCK

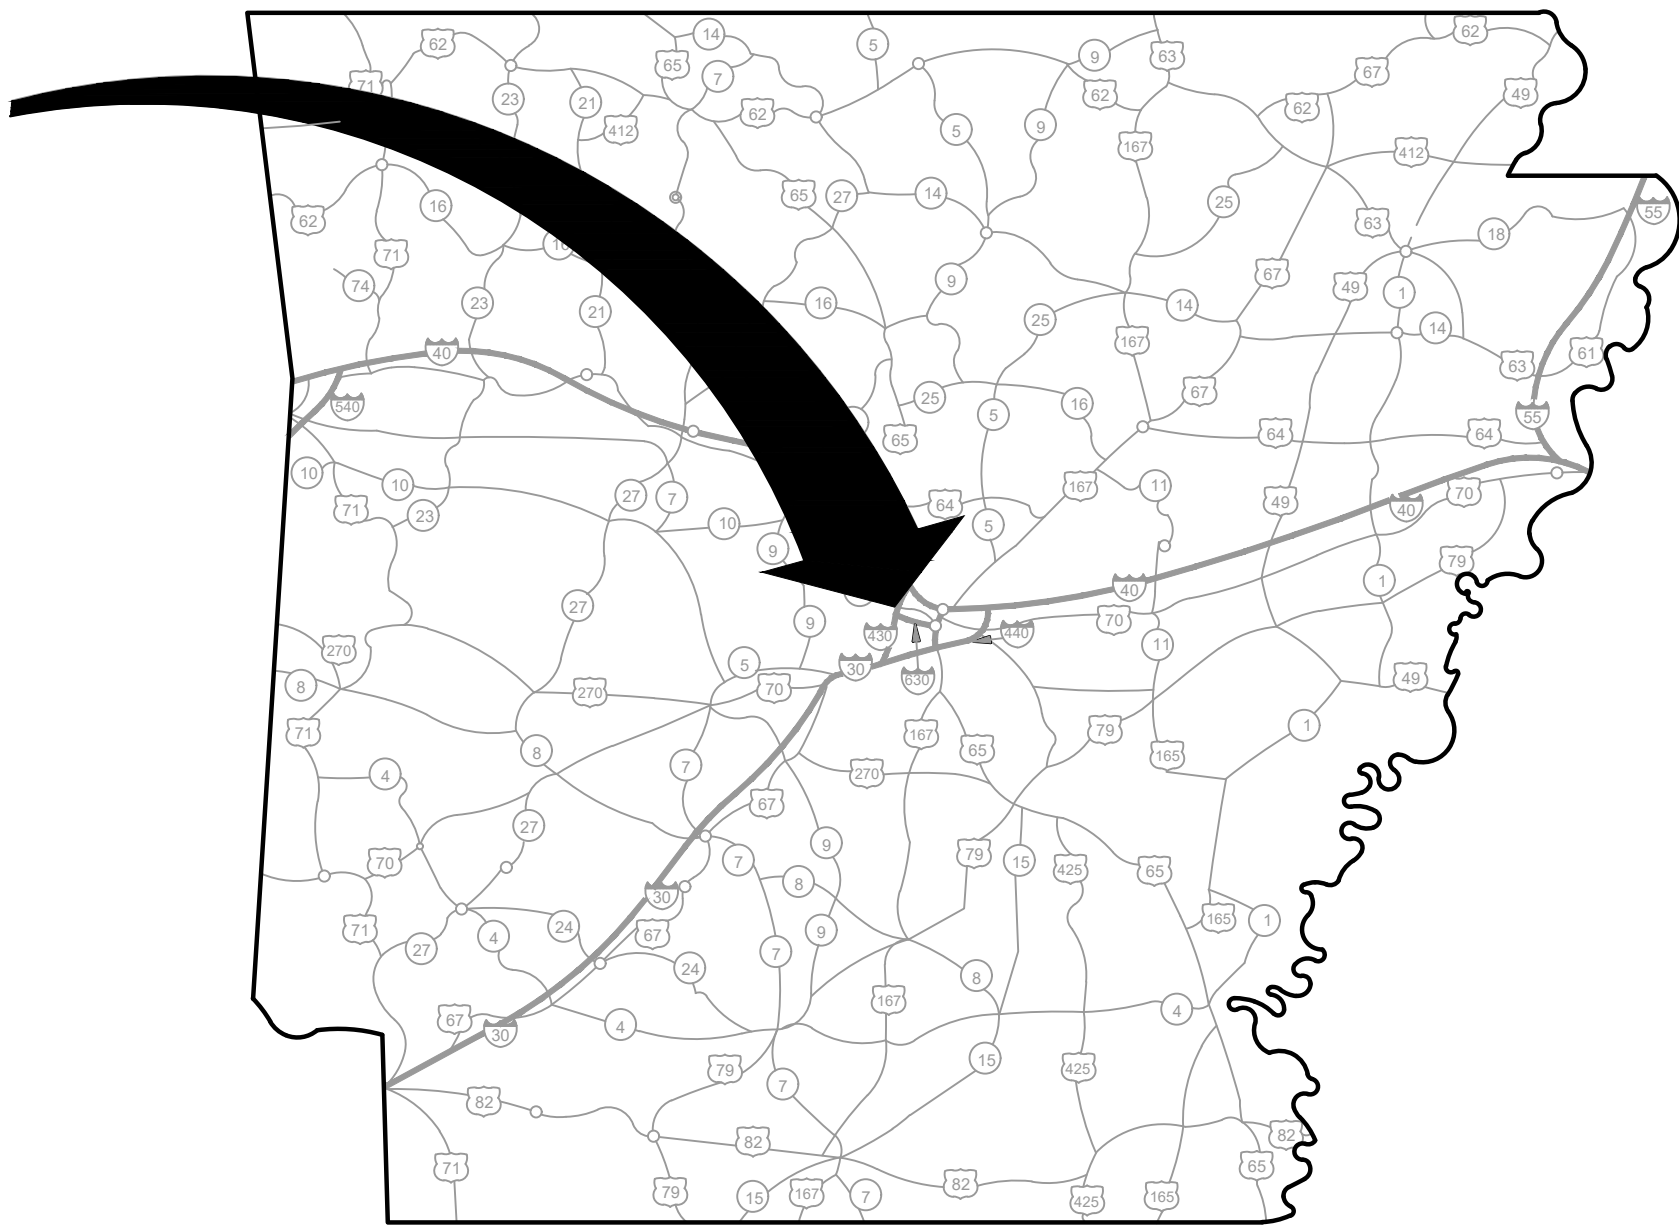

VICINITY MAP
N.T.S.

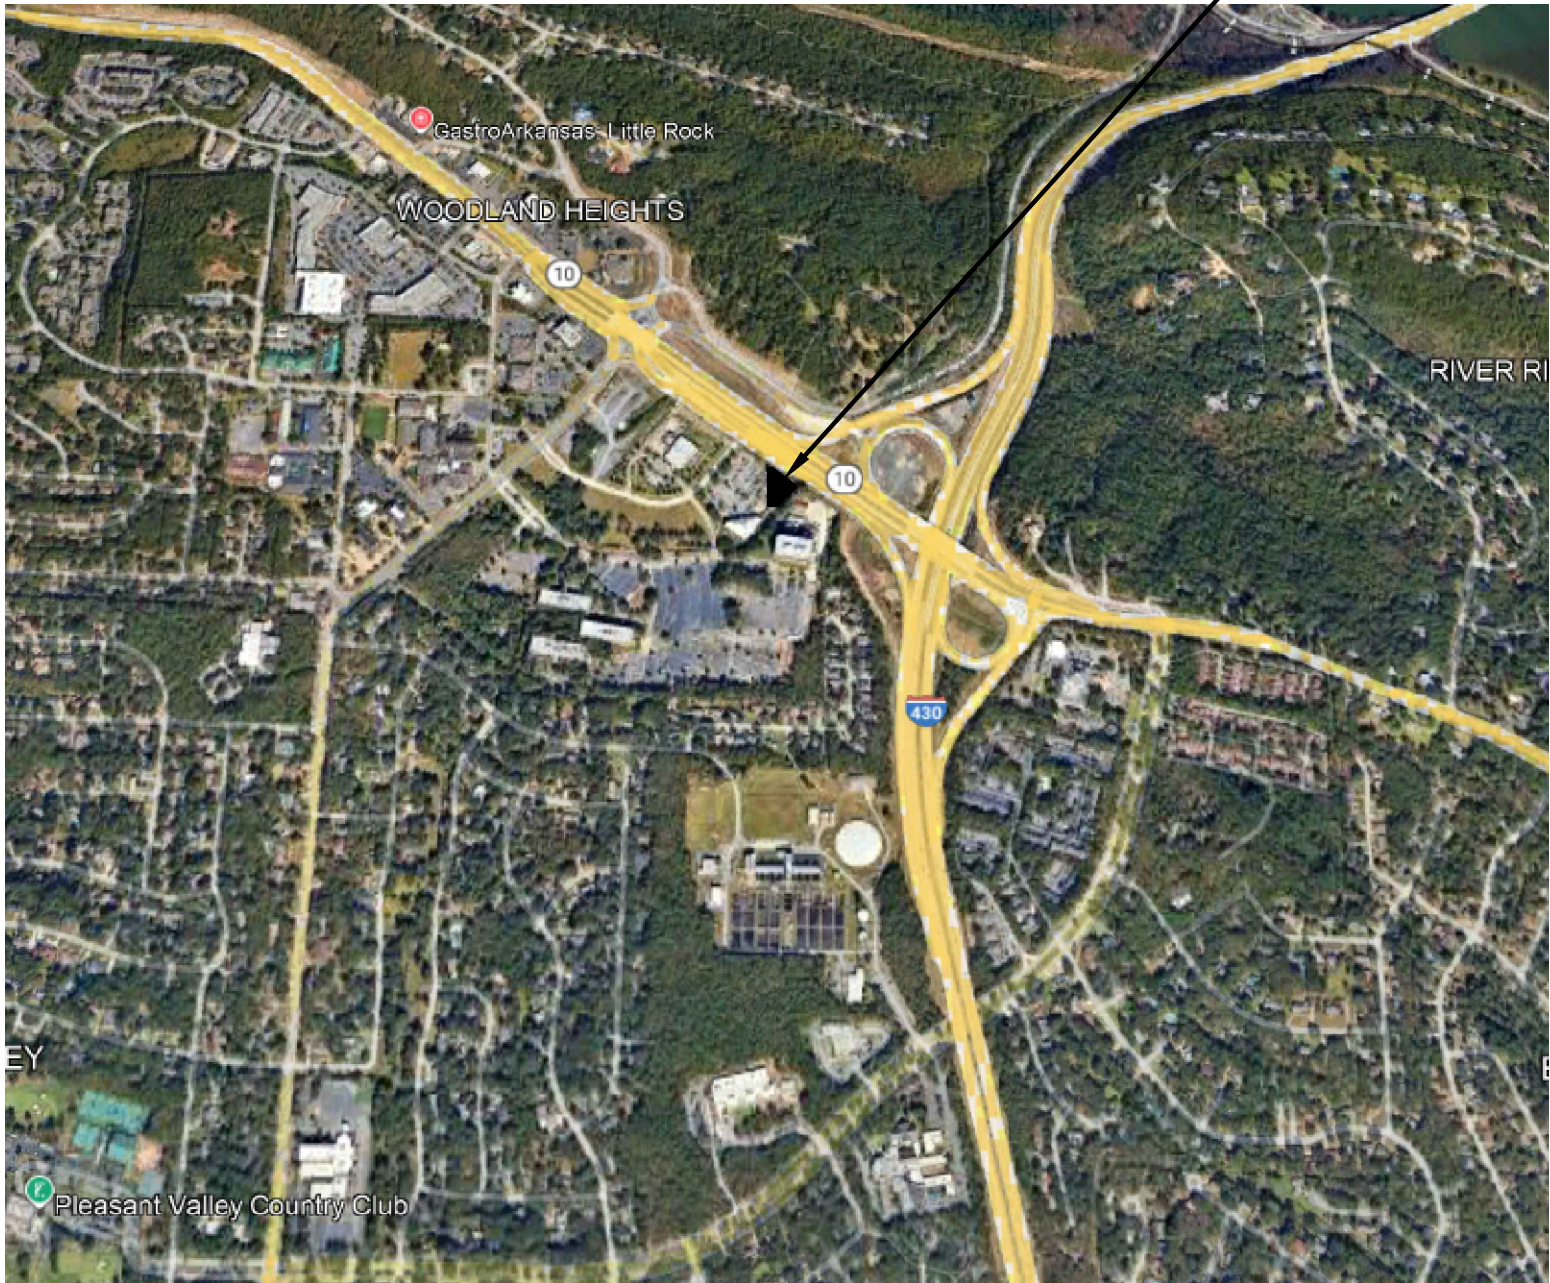

AREA MAP
N.T.S.



INDEX

SHEET NO.	SHEET TITLE
T1.01	COVER SHEET
MD1.01	MECHANICAL DEMOLITION PLAN
M1.01	MECHANICAL RENOVATION PLAN
M2.01	MECHANICAL DETAILS AND SCHEDULES
ED1.01	ELECTRICAL DEMOLITION PLAN
E1.01	ELECTRICAL RENOVATION PLAN
E2.01	ONE LINE DIAGRAM - ELECTRICAL
E2.02	ONE LINE DIAGRAM - ELECTRICAL
E2.03	FINAL ONE LINE DIAGRAM - ELECTRICAL



pettitpettit
CONSULTING ENGINEERS, INC

201 EAST MARKHAM STREET, SUITE 400 | LITTLE ROCK, AR 72201-1631 | 501.374.3731 | WWW.PETTITINC.COM

ANY PRIME CONTRACTOR BIDDING THIS PROJECT MUST BE ABLE TO PRESENT PREVIOUS EXPERIENCE WITH DATA CENTERS, CRITICAL FACILITY INFRASTRUCTURE PROJECTS INVOLVING 480V/3PH OR GREATER BUILDING PROJECTS WHERE MAINTAINING BOTH POWER AND DATA STABILITY IS CRITICAL TO THE SUCCESS OF THE PROJECT, DEMONSTRATING EXPERTISE IN CONTROL SYSTEMS, INCLUDING KEY INTERLOCK SCHEMES THAT FACILITATE SAFE BREAKER MANIPULATION, AS WELL AS DEMONSTRATING THEIR ABILITY TO ACCOMPLISH THE PROJECT SCOPE WHILE ENSURING SMOOTH TRANSITION OF POWER AND DATA WITHOUT OUTAGE.

I HEREBY CERTIFY THAT THESE PLANS AND SPECIFICATIONS HAVE BEEN PREPARED BY ME OR UNDER MY SUPERVISION. I FURTHER CERTIFY THAT TO THE BEST OF MY KNOWLEDGE, THESE PLANS AND SPECIFICATIONS ARE AS REQUIRED BY LAW AND IN COMPLIANCE WITH THE ARKANSAS FIRE PREVENTION CODE FOR THE STATE OF ARKANSAS.

[Signature]

DATE:	OCTOBER 5, 2026
JOB NUMBER:	26-006
SHEET NUMBER:	T1.01

