
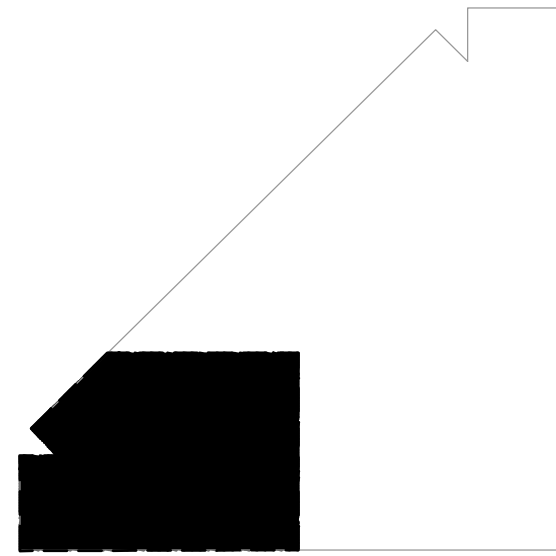
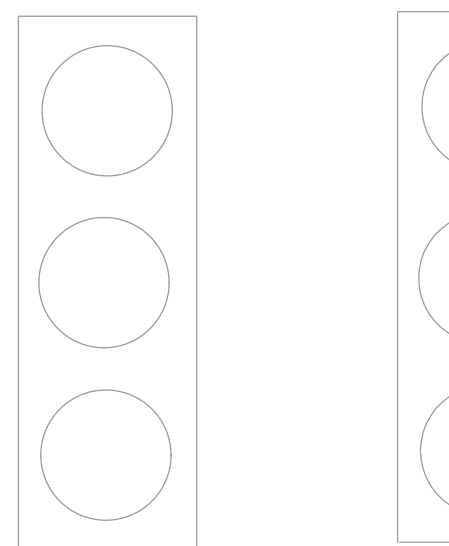
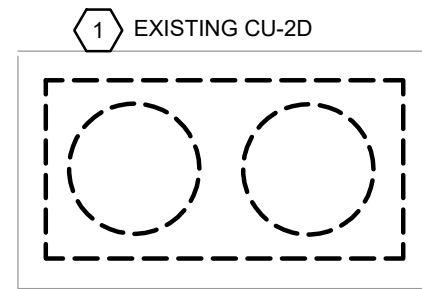
 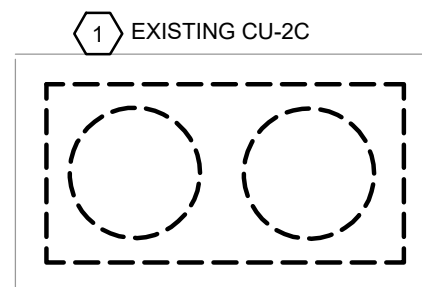

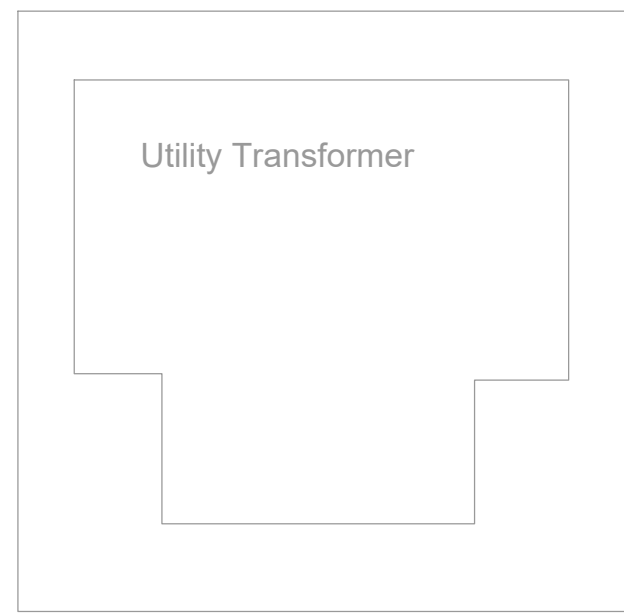


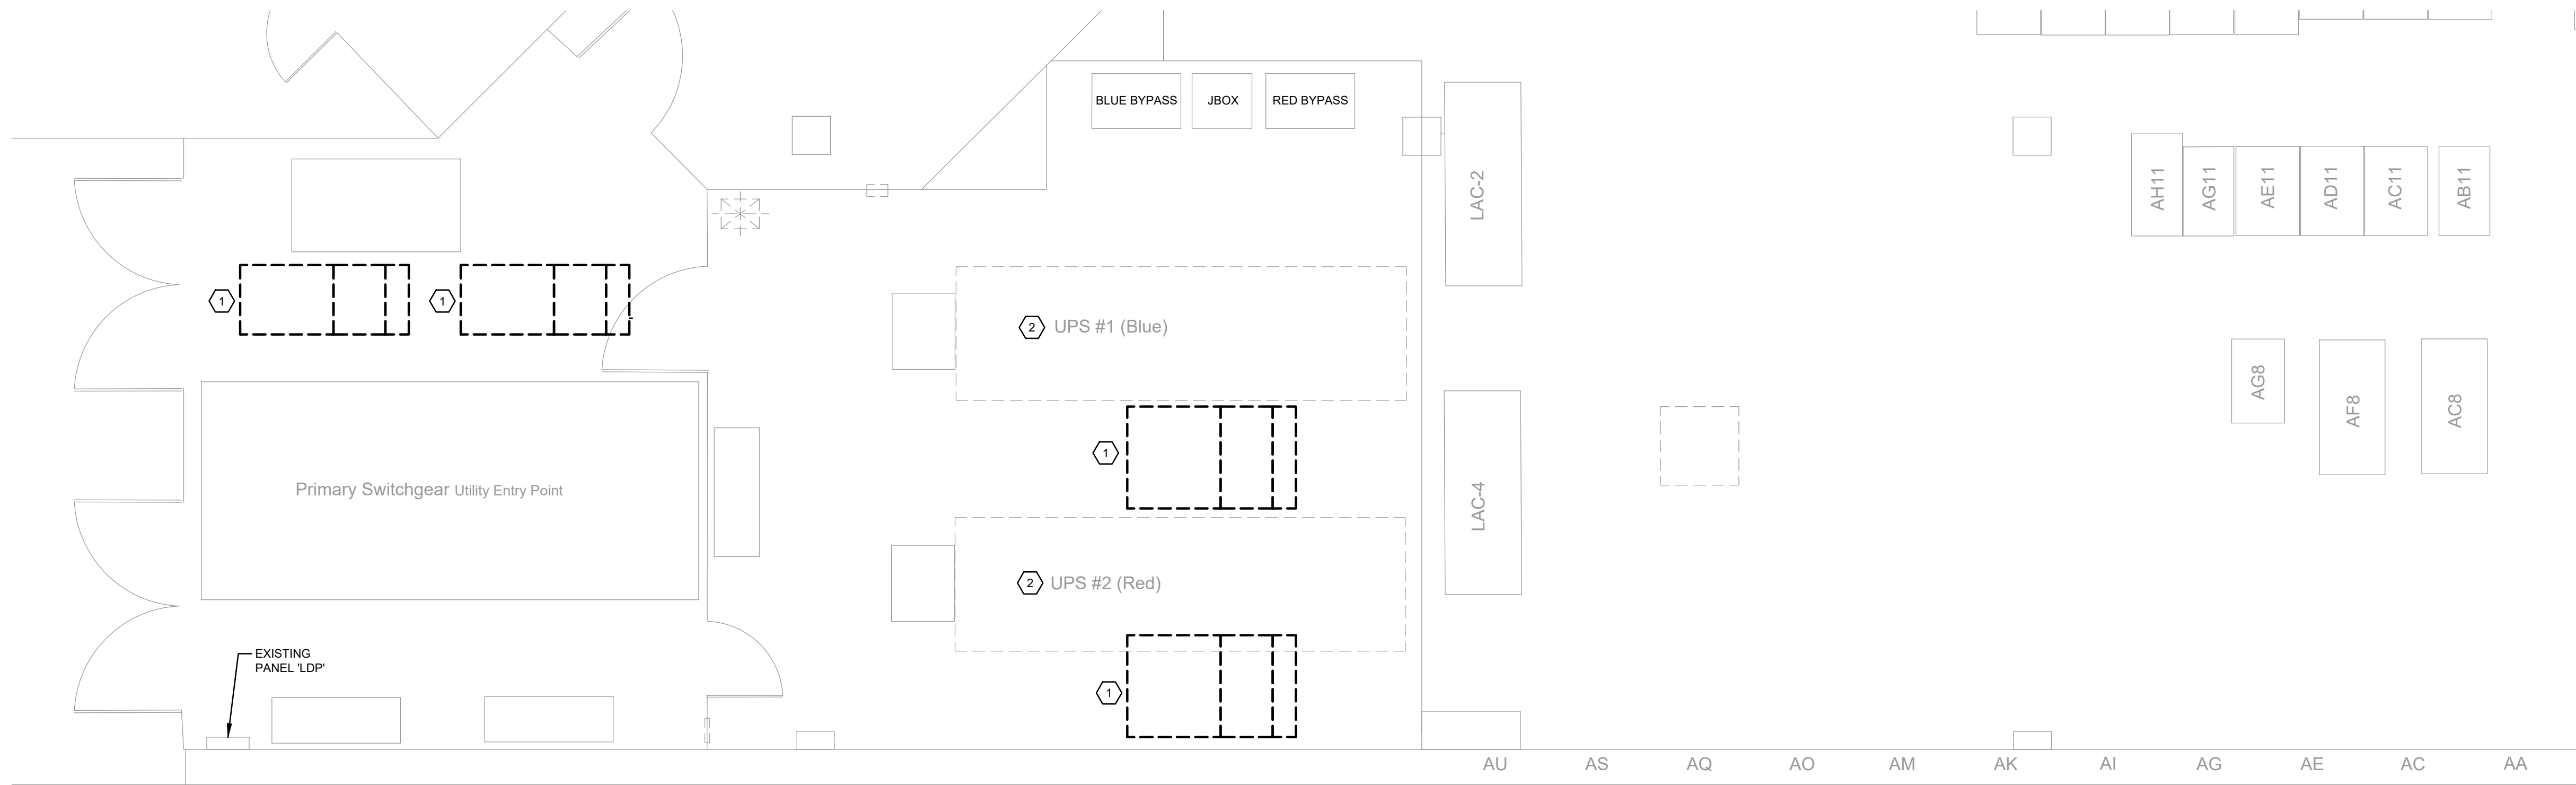

KEY PLAN

1 ELECTRICAL RENOVATION PLAN
SCALE: 1/4" = 1'-0"

DEMOLITION KEYED NOTES

- 1 REMOVE ALL ELECTRICAL COMPLETELY FROM EQUIPMENT BEING DEMOLISHED. LABEL CIRCUIT AS SPARE.
- 2 SEE SHEET E1.01 FOR THE UPS REMOVAL PROCESS.

DEMOLITION NOTES

1. THE ELECTRICAL CONTRACTOR SHALL BE REQUIRED TO VISIT THE SITE TO FAMILIARIZE HIMSELF WITH ALL EXISTING CONDITIONS PRIOR TO BID.
2. THE ELECTRICAL CONTRACTOR SHALL BE RESPONSIBLE FOR ALL ELECTRICAL DEMOLITION INDICATED ON THESE DRAWINGS. ALL WIRING DEVICES, LIGHT FIXTURES, WIRE, & CONDUIT THAT IS TO BE REMOVED SHALL BE STORED AS DIRECTED BY THE OWNER OR RELOCATES AS SHOWN ON THE NEW FLOOR PLAN. APPROPRIATE MEASURES SHALL BE TAKEN TO ASSURE CONTINUITY OF EXISTING CIRCUITS WHERE REQUIRED, AND ALL OUTAGES WHICH MAY RESULT SHALL BE COORDINATED WITH THE OWNER PRIOR TO THE WORK.
3. CONTRACTOR SHALL VERIFY ELECTRICAL ON ALL EXISTING BRANCH CIRCUITS NOTED TO BE RE-USED.
4. DASHED LINES INDICATE EXISTING EQUIPMENT, AND DEVICES, ETC., TO BE DEMOLISHED UNLESS OTHERWISE NOTED.

ANY PRIME CONTRACTOR BIDDING THIS PROJECT MUST BE ABLE TO PRESENT PREVIOUS EXPERIENCE WITH DATA CENTERS, CRITICAL FACILITY INFRASTRUCTURE PROJECTS INVOLVING 480V/3PH OR GREATER BUILDING PROJECTS WHERE MAINTAINING BOTH POWER AND DATA STABILITY IS CRITICAL TO THE SUCCESS OF THE PROJECT, DEMONSTRATING EXPERTISE IN CONTROL SYSTEMS, INCLUDING KEY INTERLOCK SCHEMES THAT FACILITATE SAFE BREAKER MANIPULATION, AS WELL AS DEMONSTRATING THEIR ABILITY TO ACCOMPLISH THE PROJECT SCOPE WHILE ENSURING SMOOTH TRANSITION OF POWER AND DATA WITHOUT OUTAGE.

