



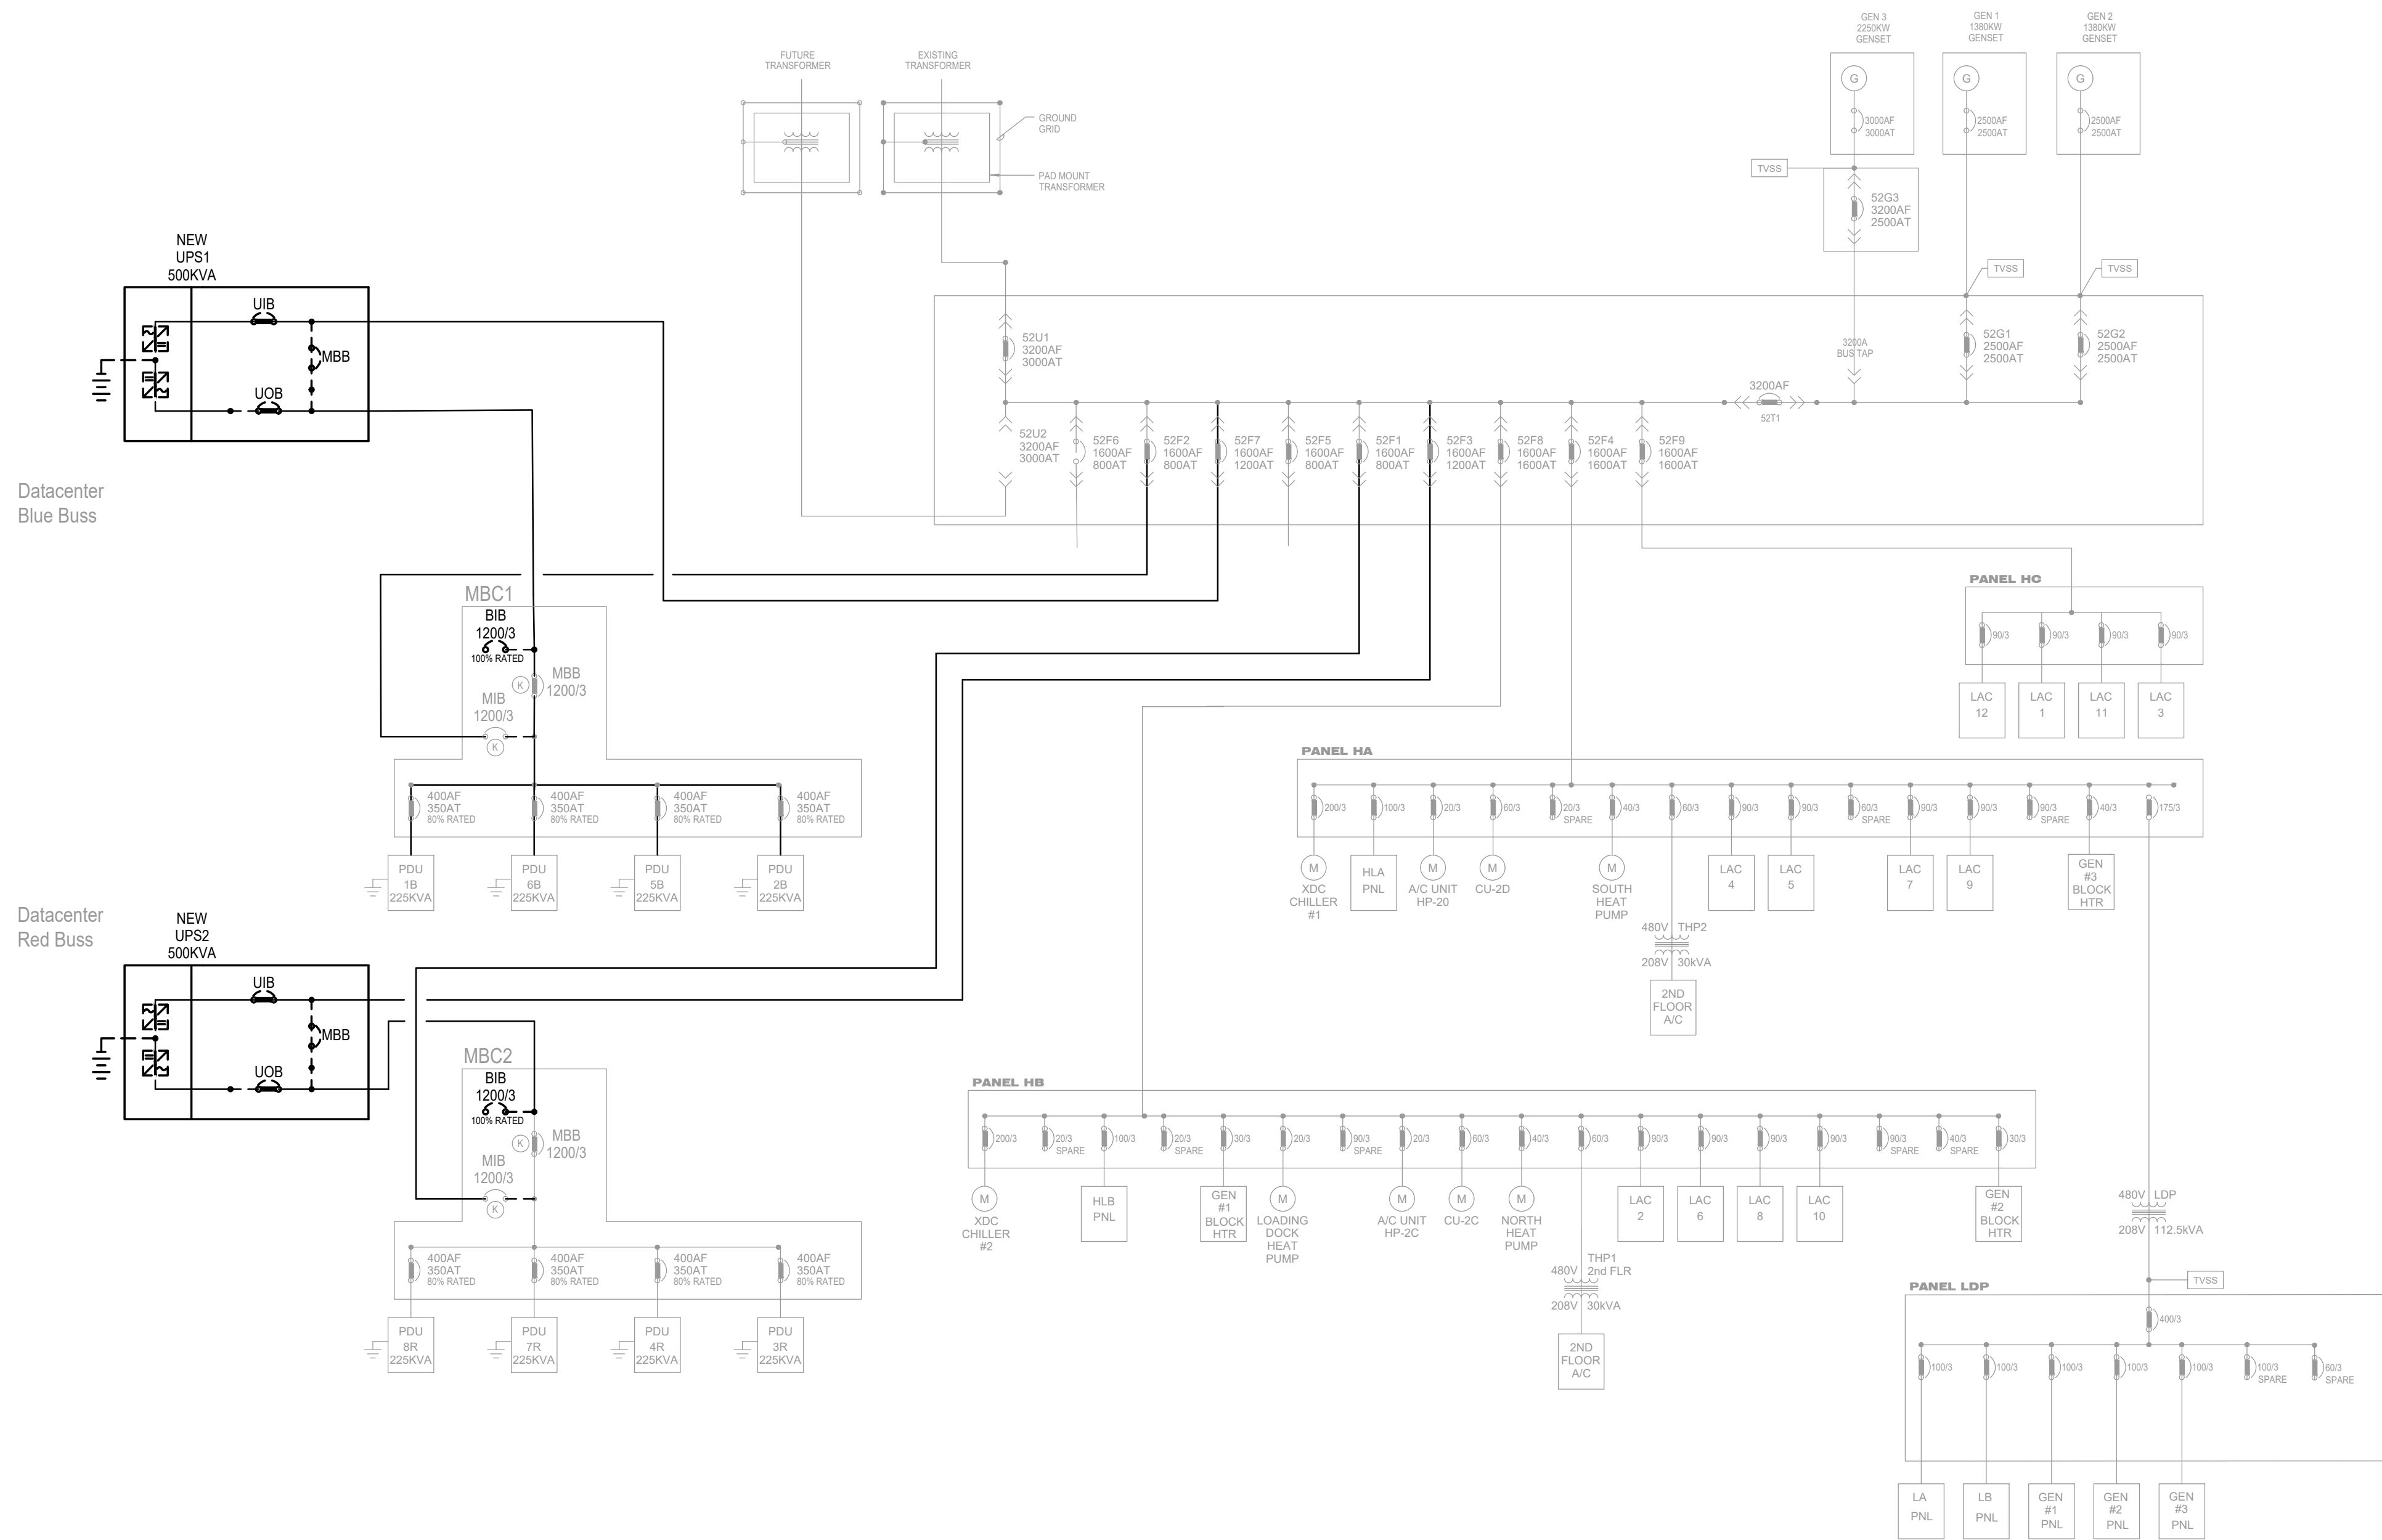

1 FINAL POWER RISER
SCALE: N.T.S.

ANY PRIME CONTRACTOR BIDDING THIS PROJECT MUST BE ABLE TO PRESENT PREVIOUS EXPERIENCE WITH DATA CENTERS, CRITICAL FACILITY INFRASTRUCTURE PROJECTS INVOLVING 480V/3PH OR GREATER BUILDING PROJECTS WHERE MAINTAINING BOTH POWER AND DATA STABILITY IS CRITICAL TO THE SUCCESS OF THE PROJECT, DEMONSTRATING EXPERTISE IN CONTROL SYSTEMS, INCLUDING KEY INTERLOCK SCHEMES THAT FACILITATE SAFE BREAKER MANIPULATION, AS WELL AS DEMONSTRATING THEIR ABILITY TO ACCOMPLISH THE PROJECT SCOPE WHILE ENSURING SMOOTH TRANSITION OF POWER AND DATA WITHOUT OUTAGE.

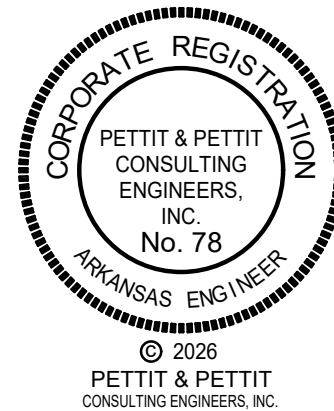

UPS REPLACEMENT
STATE DATA CENTER WEST
SAS / OFFICE OF STATE TECHNOLOGY
LITTLE ROCK, ARKANSAS

DBA PROJ# 4702501RLF
P & P JOB NO. 26-006
DESIGN TDA/BBJ
DATE 10/05/2026
SHEET NO. E2.03

Pettitpettit
CONSULTING ENGINEERS, INC.
201 EAST MARKHAM STREET, SUITE 400 | LITTLE ROCK, AR 72201-1431 | 501.374.3731 | WWW.PETTITINC.COM